


***NOTE:** PRIOR TO CONSTRUCTION, CONTRACTOR TO FIELD VERIFY LOCATION AND ELEVATION AND NOTIFY ENGINEER OF DISCREPANCIES.

PROFILE - SEWER MAINLINE


HORIZ SCALE: 1"=40'
 VERT SCALE: 1"=4'

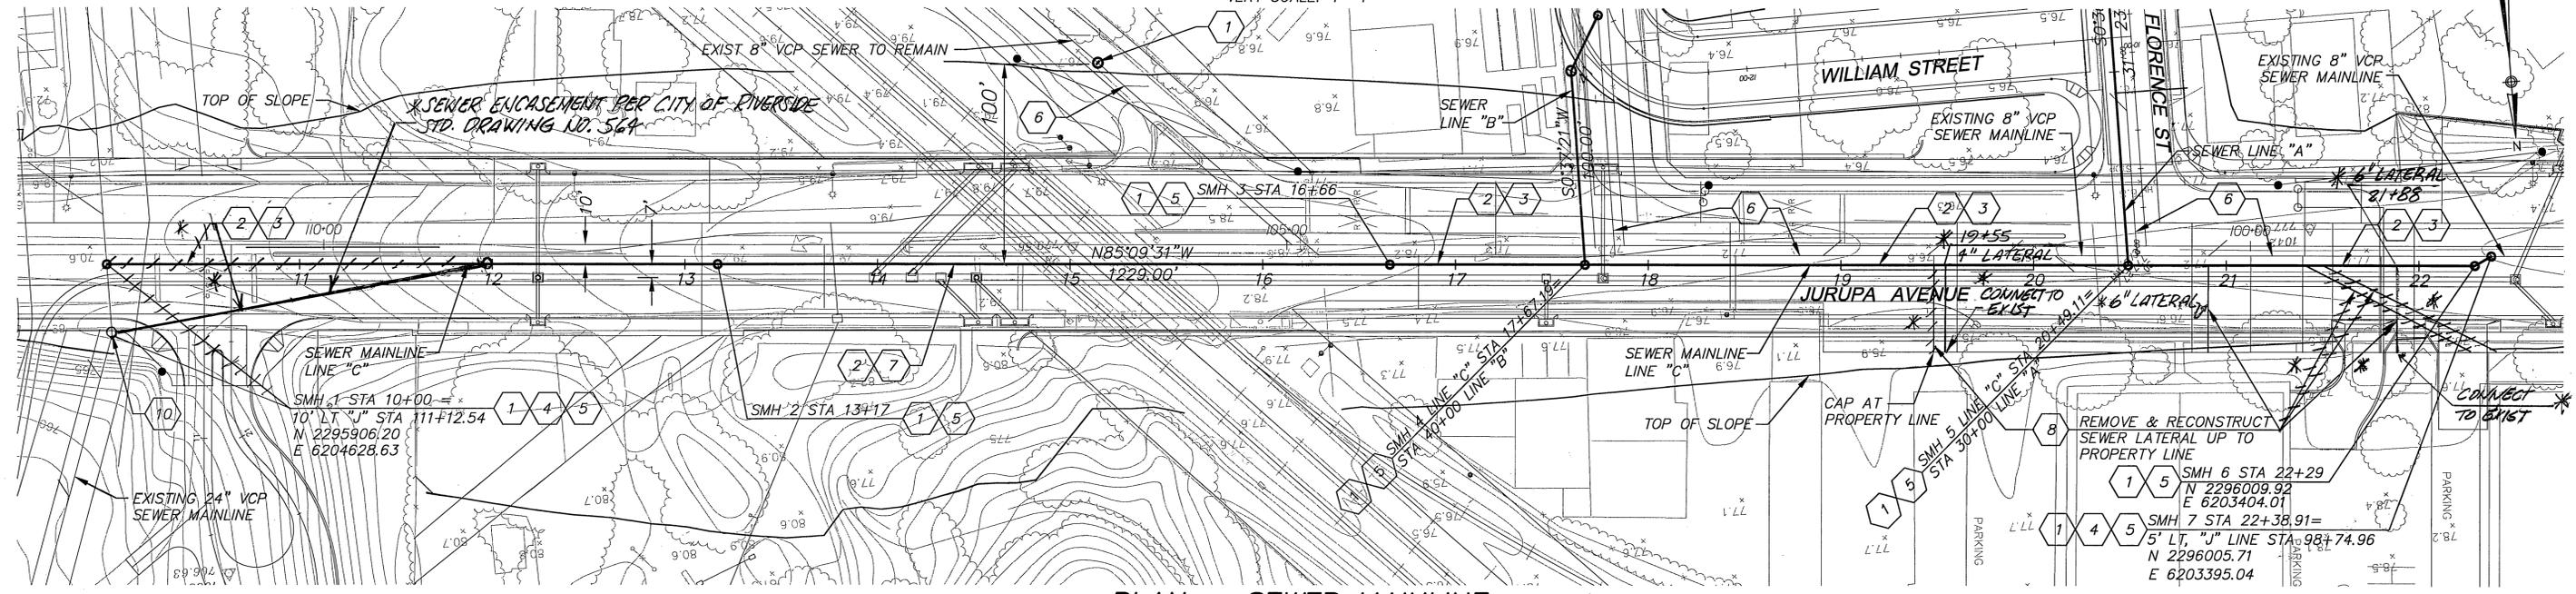

CONSTRUCTION NOTES

- 1 CONSTRUCT SEWER MANHOLE PER CITY OF RIVERSIDE STANDARD DRAWING NO 500
- 2 CONSTRUCT 8" EXTRA STRENGTH VITRIFIED CLAY PIPE (VCP) SEWER
- 3 PIPE BEDDING PER CITY OF RIVERSIDE STANDARD DRAWING NO. 452 CASE I
- 4 CONTRACTOR TO VERIFY EXISTING SEWER ELEVATION PRIOR TO CONSTRUCTION
- 5 CONTRACTOR TO ADJUST SEWER MANHOLES TO FINAL GRADE AFTER PAVING IS COMPLETED

- 6 REMOVE SANITARY SEWER FACILITIES
- 7 PIPE BEDDING PER CITY OF RIVERSIDE STANDARD DRAWING NO. 452 CASE IV

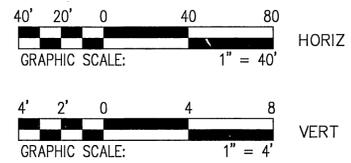

PLAN - SEWER MAINLINE

SCALE: 1"=40'


- 8 CONSTRUCT VITRIFIED CLAY PIPE SEWER LATERAL "HOUSE CONNECTION", PER CITY OF RIVERSIDE STANDARD DRAWING NO 562A
- 9 NOT USED
- 10 LOCATE EXISTING MANHOLE AND RAISE TOP TO FINISHED GRADE.

GENERAL NOTES

1. CONSTRUCTION SHALL BE IN ACCORDANCE WITH THE CITY OF RIVERSIDE PUBLIC WORKS STANDARD DRAWINGS AND STANDARD SPECIFICATIONS FOR PUBLIC WORKS CONSTRUCTION (SSPWC) 2006 EDITION
2. CONTRACTOR TO CALL UNDERGROUND SERVICE ALERT (USA) (800) 422-4133, TWO WORKING DAYS PRIOR TO DIGGING
3. PRIOR TO ISSUANCE OF GRADE SHEETS FOR ANY PROPOSED SEWER AND STORM DRAIN FACILITIES CONTRACTOR SHALL EXPOSE ALL UTILITIES WHICH CROSS OR MAY BE IN CONFLICT WITH THE PROPOSED SEWER AND STORM DRAIN FACILITIES AND COORDINATE WITH THE INSPECTOR TO HAVE THE LOCATION AND ELEVATION VERIFIED BY CONTRACTOR'S SURVEYORS.

* AS BUILT 1-20-10

DMJM HARRIS | AECOM
 999 Town & Country Road
 Orange, CA 92668
 T 714.567.2501 F 714.567.2441

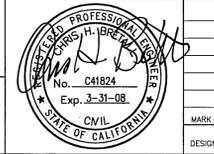

MARK	REVISIONS	APPR.	DATE

CITY OF RIVERSIDE, CALIFORNIA PUBLIC WORKS DEPARTMENT			
APPROVED BY	BY	DATE	APPROVED BY
CONST. CONTRACT ADMIN.	PC	10/10/06	DMJM HARRIS
PRINCIPAL ENGINEER	PA	12/16/06	DAN BOYD
SUBVISOR	SA	12/16/06	
TRAFFIC DIVISION	TD	12-16-06	
PARKS DEPARTMENT	PD		

JURUPA AVENUE UNDERPASS
 PHASE II CONSTRUCTION
 PLAN AND PROFILE
 SANITARY SEWER SHT 1

S-1760
 SS-01
 SHEET _____ OF _____
 October 6, 2006

