


- STREET LIGHT LEGEND AND NOTES**
- INDICATES CITY OF RIVERSIDE MARBLEITE LIGHT STANDARD NO. 4504 WITH 1000-LUMEN, TYPE II EXCEPT AS NOTED. LUMINAIRE MATERIAL "MERCURY VAPOR" LUMINAIRE WITH COLOR CORRECTED LAMP, CAT. NO. LM4441 OR APPROX. EQUAL.
  - INDICATES NO. 3 1/2 PULL BOX "BROOKS PRODUCT INC." OR APPROX. EQUAL.
  - INDICATES 1" RIGID GALV. STEEL CONDUIT, EXCEPT AS NOTED.
  - INDICATES FEED POINT.
- NOTES:**
1. ALL STREET LIGHT STANDARDS AND PULL BOXES TO BE LOCATED IN THE FIELD.
  2. ALL STREET LIGHT STANDARDS SHALL BE CHECKED FOR CLEARANCE OF DRIVEWAYS AND PLACED 1' FROM END OF CURBS/RETURNS.
  3. SEE CITY OF RIVERSIDE DRWG. NO. L1-1900B FOR LIGHT STANDARD DETAILS AND DRWG. NO. L1-1900C FOR PULL BOX DETAILS.
  4. ALL CABLE TO BE AWG NO. 8 COPPER.
  5. THIS IS A 2 WIRE 240 VOLT MULTIPLE SYSTEM.
  6. ALL CONSTRUCTION TO COMPLY WITH CITY OF RIVERSIDE STREET LIGHT SPECIFICATIONS.
  7. FEED POINT TO BE CONFIRMED AT TIME OF CONSTRUCTION.
  8. \$75.00 CONNECTION FEE PAID 6-14-65.
  9. INSPECTIONS TO BE CALLED FOR AS OUTLINED IN SPECIFICATIONS.

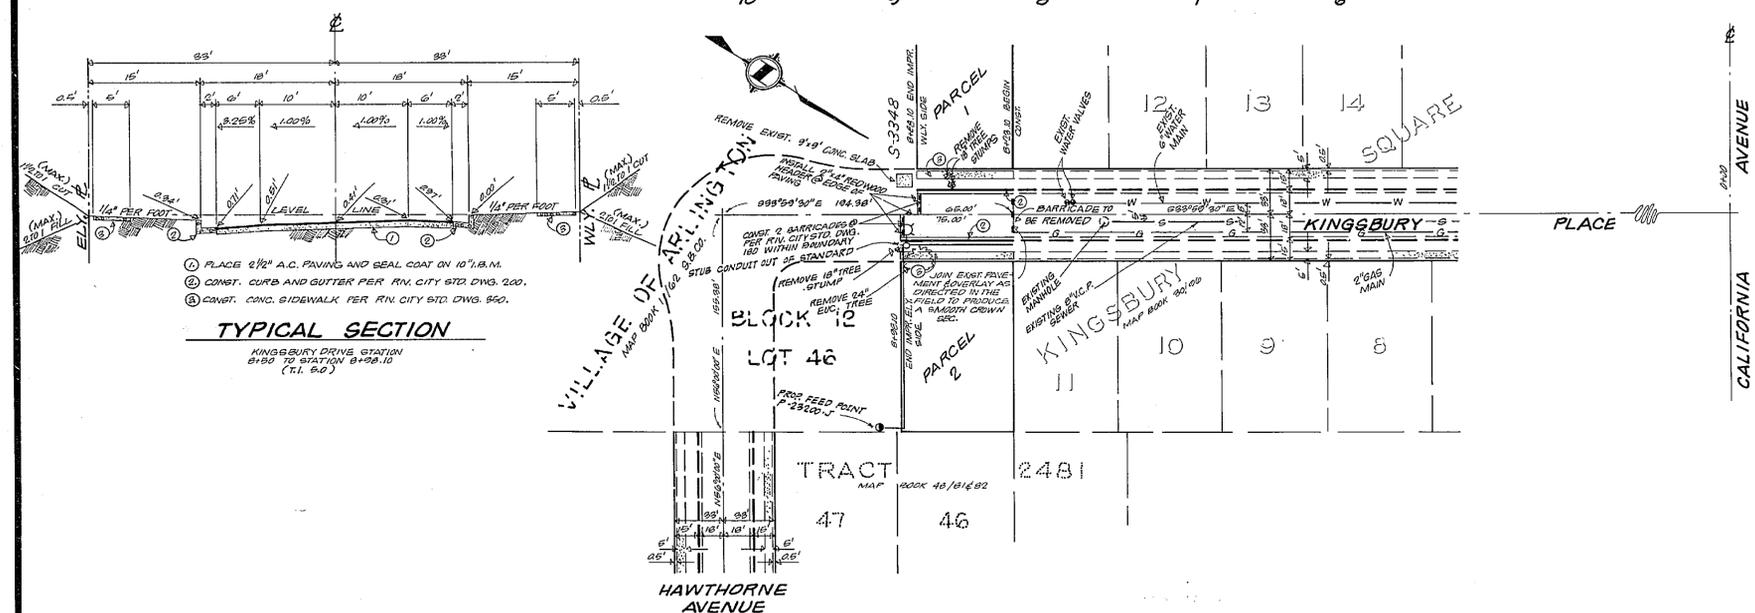

<b>J. F. DAVIDSON ASSOCIATES</b> CIVIL ENGINEERS - SURVEYORS - PLANNERS RIVERSIDE, CALIFORNIA		<b>CITY OF RIVERSIDE, CALIFORNIA</b> DEPARTMENT OF PUBLIC WORKS		PROJECT NO. <b>R-1039</b>
APPROVED BY: <i>De Campbell</i> GENERAL SUPT. & CHIEF ENGR. DATE: 6-15-65		APPROVED BY: <i>W. J. ...</i> DIRECTOR OF PUBLIC WORKS DATE: 7-12-65		SHEET 1 OF 1
W.D. 418 FOR: ELLEN D. MORE P.B. 800		DESIGNED BY: <i>...</i> DRAWN BY: <i>...</i> CHECKED BY: <i>...</i>		FILE NO. 2791
HORIZ. SCALE: 1" = 50'		VERT. SCALE: 1" = 5'		STREETS PLAN AND PROFILE <b>KINGSBURY PLACE</b> 825.20' TO 828.20' ELY. OF THE C. OF CALIFORNIA AVENUE <b>R/G. 903</b>