



SEE GENERAL NOTE #21

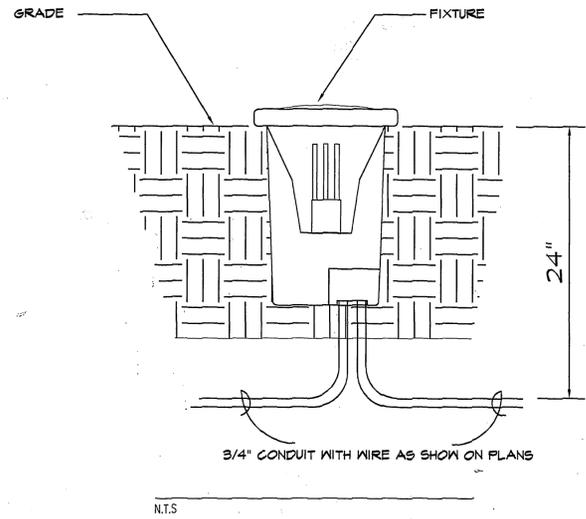


N.T.S.

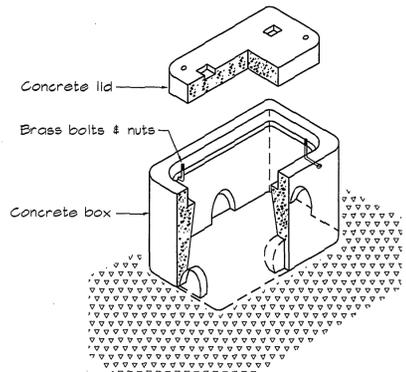


PLACE PULL BOX ON 12" OF CRUSHED ROCK. ROCK BASE SHALL BE 6" LARGER IN ALL DIMENSIONS THAN PULL BOX.

N.T.S.

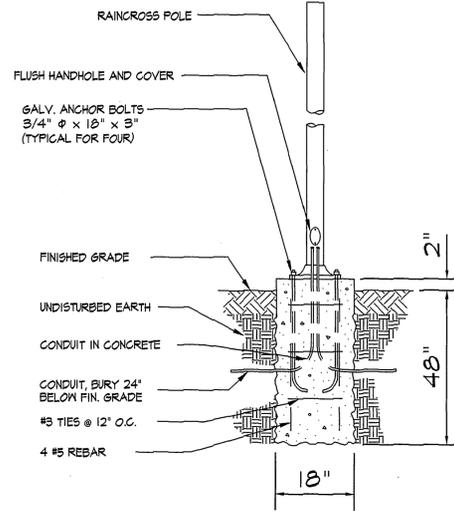

N.T.S.

SEE GENERAL NOTE #19

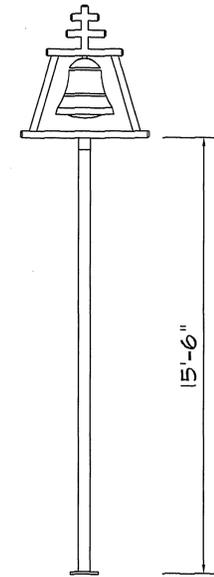

N.T.S.


1. PROVIDE ALL MATERIALS AND LABOR AS REQUIRED TO ACHIEVE A COMPLETE AND OPERATING SYSTEM.
2. COORDINATE AND OBTAIN APPROVALS FROM ALL RESPECTIVE UTILITY COMPANIES AS REQUIRED FOR A COMPLETE AND OPERATING INSTALLATION.
3. INSTALL RACEWAY SYSTEMS WITH A MINIMUM OF 24" COVER AS FOLLOWS:
 - a. USE RIGID GALVANIZED STEEL IN ALL AREAS EXPOSED TO WEATHER OR PHYSICAL DAMAGE.
 - b. USE P.V.C. CONDUIT UNDERGROUND WITH CODE SIZED GROUND.
4. ALL NEW WIRING SHALL BE COPPER TYPE "THHN/THWN" - U.O.N.
5. ALL FIXTURE, DEVICE, ETC., LOCATIONS SHALL BE VERIFIED WITH ARCH. DRAWINGS AS WELL AS EQUIPMENT SUPPLIER REQUIREMENTS PRIOR TO ANY ROUGH-IN WORK.
6. ALL LIGHTING FIXTURES SHALL BE MOUNTED AND SUPPORTED IN ACCORDANCE WITH OSHA STANDARDS AND ALL NATIONAL AND LOCAL ELECTRICAL CODES.
7. THESE DRAWINGS ARE DIAGRAMMATIC AND REPRESENT THE INTENT OF EQUIPMENT, DEVICES, ETC., TO BE CONNECTED AND THE CIRCUITS TO WHICH THEY ARE TO BE CONNECTED TO. CONTRACTOR SHALL INSTALL ALL CONDUIT, J-BOXES, ETC., AS REQUIRED FOR A COMPLETE AND OPERATING SYSTEM.
8. ELECTRICAL CONTRACTOR SHALL PERFORM ALL WORK IN STRICT ACCORDANCE WITH ALL LOCAL AND NATIONAL GOVERNING CODES.
9. ALL EQUIPMENT SHALL BE NEW AND BEAR A "UL" LABEL - U.O.N.
10. ELECTRICAL CONTRACTOR SHALL SECURE AND PAY FOR ALL NECESSARY BUILDING PERMITS.
11. COMPLETE ELECTRICAL INSTALLATION SHALL BE GUARANTEED IN WRITING FOR A PERIOD OF (1) YEAR - U.O.N.
12. ELECTRICAL CONTRACTOR SHALL VISIT SITE PRIOR TO BID DATE, TO VERIFY ALL EXISTING CONDITIONS TO BE ENCOUNTERED IN THE INSTALLATION OF ALL NEW EQUIPMENT, FIXTURES, DEVICES, FEEDERS, ETC., EXACT INSTALLATION METHOD AND REQUIREMENTS SHALL BE VERIFIED AND DETERMINED PRIOR TO BID DATE. CONTRACTORS SHALL IMMEDIATELY NOTIFY THIS ENGINEER OF ANY REQUIRED MODIFICATIONS WHICH ARE NOT SHOWN IN THESE DRAWINGS. SUBMITTAL OF BID INDICATES CONTRACTOR IS COGNIZANT OF ALL JOB SITE CONDITIONS AND WORK TO BE PERFORMED.
13. ALL EQUIPMENT ELECTRICAL CHARACTERISTICS, LOCATIONS, AND CONNECTION REQUIREMENTS SHALL BE VERIFIED PRIOR TO ANY ROUGH-IN WORK.
14. ELECTRICAL CONTRACTOR SHALL FURNISH THE FOLLOWING SHOP DRAWINGS FOR PRIOR APPROVAL:
 - a. ALL LIGHT FIXTURES.
 - b. ALL ELECTRICAL SERVICE EQUIPMENT, DISTRIBUTION EQUIPMENT AND CONTACTORS.
 - c. OTHER ITEMS AS SPECIFICALLY INDICATED.
15. THESE ITEMS SHALL BE APPROVED BY THIS OFFICE PRIOR TO ANY COMMENCEMENT OF PLACING ORDERS OR PERFORMING ANY ROUGH-IN WORK.
16. COMPLETE ELECTRICAL SYSTEM SHALL BE GROUNDED IN ACCORDANCE WITH THE PRESENTLY ADOPTED EDITION OF THE N.E.C. ART. 250.
17. PROVIDE ENGRAVED PLASTIC NAMEPLATES FOR ALL MAJOR ELECTRICAL EQUIPMENT.
18. PROVIDE THE OWNER AND THIS ENGINEER WITH ONE SET OF ELECTRICAL "AS-BUILTS" AT THE COMPLETION OF JOB.
19. RAINCROSS LIGHTS AND POLES ARE PER CITY OF RIVERSIDE STANDARD SPECIFICATION DRAWING No. L5-13344. FIXTURES ARE 100 WATT HIGH PRESSURE SODIUM - 120 VOLT. USE SYLVANIA LAMP L1000. FOR ORDERING INFORMATION CONTACT SOUTH COAST LIGHTING (714) 365-0054.
20. ENTRY WALL FLOOD LIGHTS ARE HADCO CATALOG No. WA3-G-HF-N-175H-E-S18G. USE SYLVANIA LAMP M175/C/U/MED LAMP. NO KNOWN EQUAL TO FIXTURE. TWO FIXTURES PER MOUNTING.
21. DISPLAY PEDESTAL UP LIGHTS ARE HADCO CATALOG No. 13-G-H-FL-42 PLT-E. USE SYLVANIA LAMP CF42DT/E/IN/B35. NO KNOWN EQUAL TO FIXTURE.
22. CONCRETE PULL BOXES TO BE CHRISTY B12 UTILITY BOX WITH B12C LID MARKED "ELECTRICAL". NO KNOWN EQUAL.
23. ROUNDABOUT PEDESTAL AUTO LIGHTS ARE HADCO CATALOG No. WA3-G-HF-N-175H-E WITH SS18-G. USE SYLVANIA LAMP M175/U/MED. NO KNOWN EQUAL TO FIXTURE. ONE FIXTURE PER MOUNTING.
24. NOT USED
25. METER PEDESTALS TO BE PACIFIC UTILITY PRODUCTS CATALOG No. USP24-M200-124TB-SS WITH PHOTOCELL RECEPTACLE AND INTERMATIC LC4521 PHOTOCELL (DELAY TYPE). PROVIDE PE SHIELD FROM ENCLOSURE MFG. PROVIDE WITH CE CR353AD3B41 2 POLE 40 AMP INDUCTIVE CONTACTORS WITH LINE AND LOAD LUGS. PROVIDE ONE (1) CONTACTOR FOR EACH TWO (2) CIRCUITS. KEEP CIRCUITS FOR RAINCROSS LIGHTS SEPARATE FROM CIRCUITS FOR SIGNS AND UP-LIGHTS.

UP LIGHT FOR DISPLAY PEDESTALS

CONCRETE PULL BOX


RAINCROSS POLE BASE DETAIL

RAINCROSS LIGHT

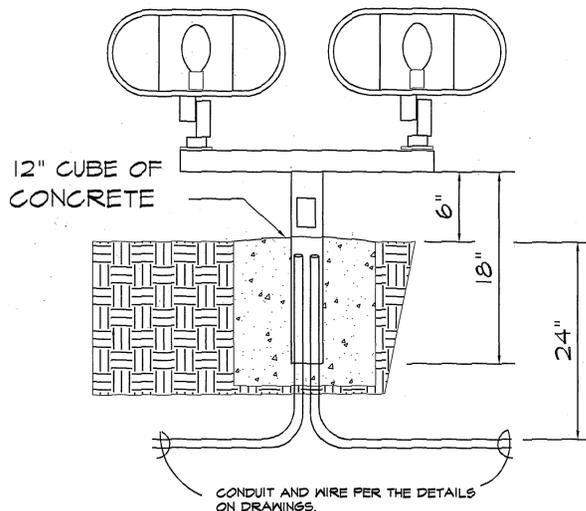


SEE GENERAL NOTE #20

N.T.S.

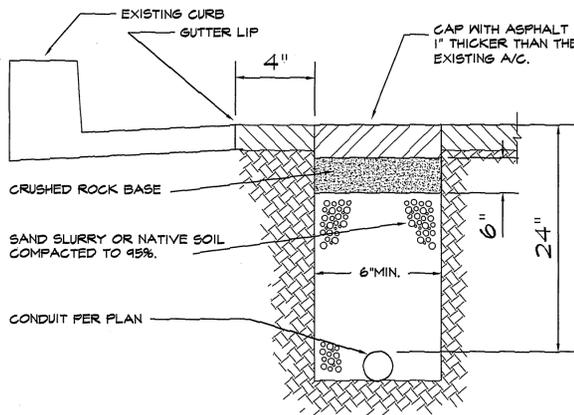

NOT TO SCALE

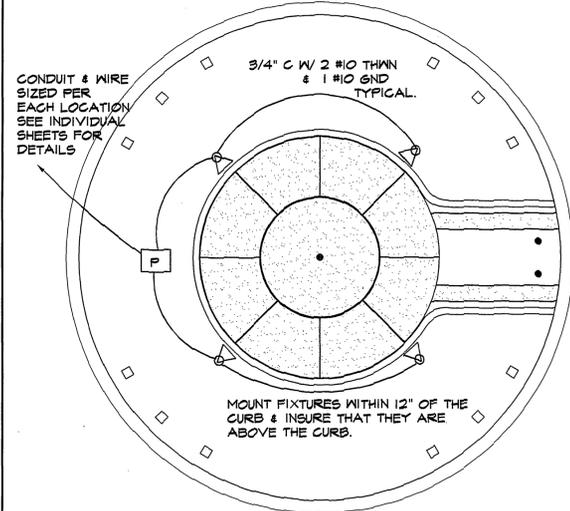

SEE GENERAL NOTE #23

ROUNDABOUT PEDESTAL PLAN VIEW

N.T.S.

ENTRY WALL FLOOD LIGHT DETAIL

TRENCHING DETAIL FOR CONDUIT IN RIGHT OF WAY

DISPLAY LIGHTING PLAN

GENERAL NOTES

- 1 3/4" C. W 2-#10 & #10 G.
- 2 3/4" C. W 3-#10 & #10 G.
- 3 1" C. W 2-#10, 3-#4 & #8 G.
- 4 3/4" C. W 2-#8 & #10 G.
- 5 1" C. W 3-#8 & #10 G.
- 6 1" C. W 3-#8 & #10 G.
- 7 1" C. W 2-#8, 2-#6 & #10 G.
- 8 1 1/4" C. W 2-#8, 2-#4 & #8 G.
- 9 1 1/4" C. W 2-#8, 3-#4 & #8 G.
- 10 1 1/4" C. W 3-#8, 2-#6 & #8 G.
- 11 1 1/4" C. W 3-#8, 6-#6 & #10 G.
- 12 1 1/4" C. W 6-#8, 3-#6 & #10 G.
- 13 1 1/4" C. W 6-#8, 2-#4 & #8 G.
- 14 1" C. W 2-#6 & #10 G.
- 15 1" C. W 3-#6 & #10 G.
- 16 1 1/4" C. W 6-#6 & #10 G.
- 17 1 1/4" C. W 3-#8, 2-#4 & #8 G.
- 18 1 1/4" C. W 3-#8, 3-#4 & #8 G.
- 19 1" C. W 2-#4 & #8 G.
- 20 1 1/4" C. W 3-#4 & #8 G.
- 21 1 1/4" C. W 3-#8, 3-#6 & #10 G.
- 22 1" C. W 2-#8, 3-#6 & #10 G.
- 23 1 1/2" C. W 3-#8, 3-#6, 2-#4 & #8 G.

CONDUIT AND WIRE SCHEDULE



METER NUMBER AND CIRCUIT NUMBER


File

Underground Service Alert
Call: TOLL FREE
1 - 800
422 - 4133

TWO WORKING DAYS BEFORE YOU DIG

PRIVATE ENGINEERING NOTE

CONSTRUCTION CONTRACTOR AGREES THAT IN ACCORDANCE WITH GENERALLY ACCEPTED CONSTRUCTION PRACTICES, CONSTRUCTION CONTRACTOR WILL BE REQUIRED TO ASSUME SOLE AND COMPLETE RESPONSIBILITY FOR JOB SITE CONDITIONS DURING THE COURSE OF CONSTRUCTION OF THE PROJECT, INCLUDING SAFETY OF ALL PERSONS AND PROPERTY, THAT THIS REQUIREMENT SHALL BE MADE TO APPLY CONTINUOUSLY AND NOT BE LIMITED TO NORMAL WORKING HOURS, AND CONSTRUCTION CONTRACTOR PARTNER AGREES TO PERFORM, INDUSTRY AND FIELD DESIGN PROFESSIONAL, HARMLESS FROM ANY AND ALL LIABILITY, REAL OR ALLEGED, IN CONNECTION WITH THE PERFORMANCE OF WORK ON THIS PROJECT, KEEPING LIABILITY ARISING FROM THE SOLE NEGLIGENCE OF DESIGN PROFESSIONAL.

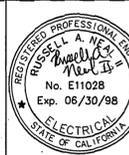

WEST COAST DESIGN

ELECTRICAL AND LIGHTING ENGINEERS
26692 PASO BRILLO, SUITE 200
SAN JUAN CAPISTRANO, CA 92675
(714) 240-1578 FAX 240-1782



J.F. DAVIDSSON ASSOCIATES, INC.

- CIVIL ENGINEERS - SURVEYORS - PLANNERS -
1777 ATLANTA ST., STE. G-5 RIVERSIDE, CA 92507 (909)886-0844 FAX 909-688-5954
27349 JEFFERSON ST. TEMECULA, CA 92590 (909)878-7710 FAX 909-699-1981
75-150 SHERYL AVE. STE.D PALM DESERT, CA 92260 (619)346-2210 FAX (619)346-7772

SCALE: 1"=40'

BENCH MARK: RIV. CO. BM 601-21-68, CALTRANS BRASS DISK SET IN CONC. WELL LOCATED IN CENTERLINE OF MONROE STREET 40' NW OF INDIANA AVENUE ELEVATION: 810.933

DATE: APRIL 18, 1997

ADDED DETAILS FOR ROUNDABOUT LIGHTS

9-23

MARK REVISIONS APPR. DATE
DESIGNED BY RO DRAWN BY RO CHECKED BY RN

CITY OF RIVERSIDE, DEPARTMENT OF PUBLIC WORKS

APPROVED BY BY DATE APPROVED BY
PRINCIPAL ENGR.
PARK DEPARTMENT
TRAFFIC DIVISION
CHIEF P.W. ENGR.
DATE

IN THE CITY OF RIVERSIDE, COUNTY OF RIVERSIDE, STATE OF CALIFORNIA

AUTO CENTER RENOVATION PLAN

DETAILS AND NOTES

AUTO DRIVE

FOR: RIVERSIDE AUTO CENTER ASSESSMENT DISTRICT

STREET LIGHTING




R-3471

SHEET E1 of 10

FILE NO.: 9613380

INDEXED 12-26-01 L4

C:\AUTOMALL\3SHEET1 Med Oct 1 11:27:27 1997

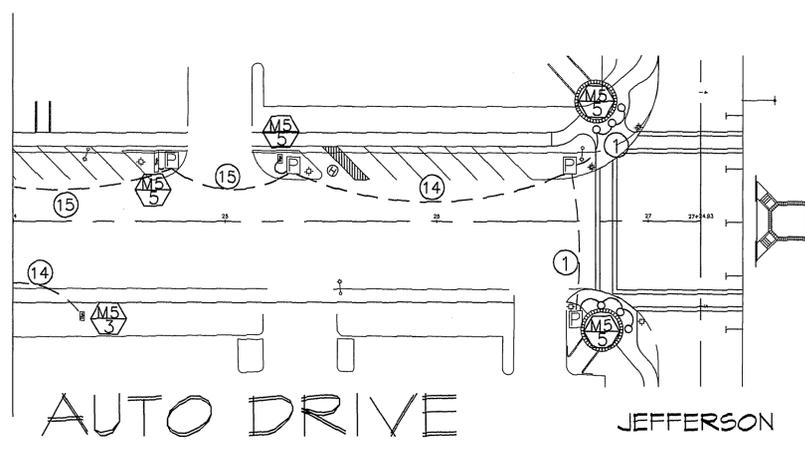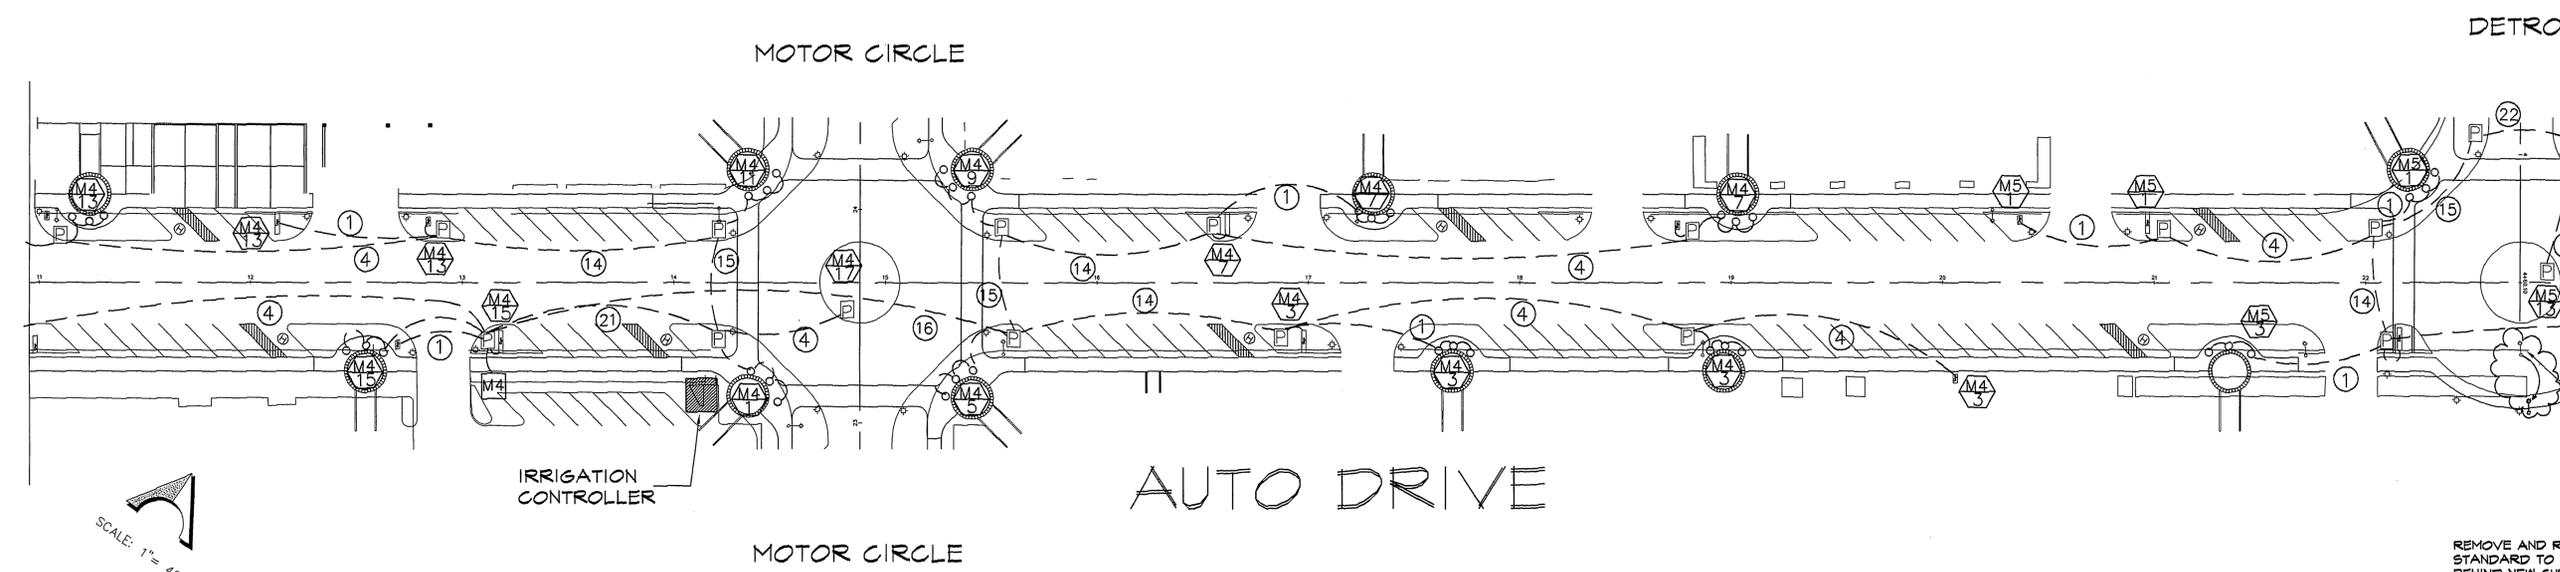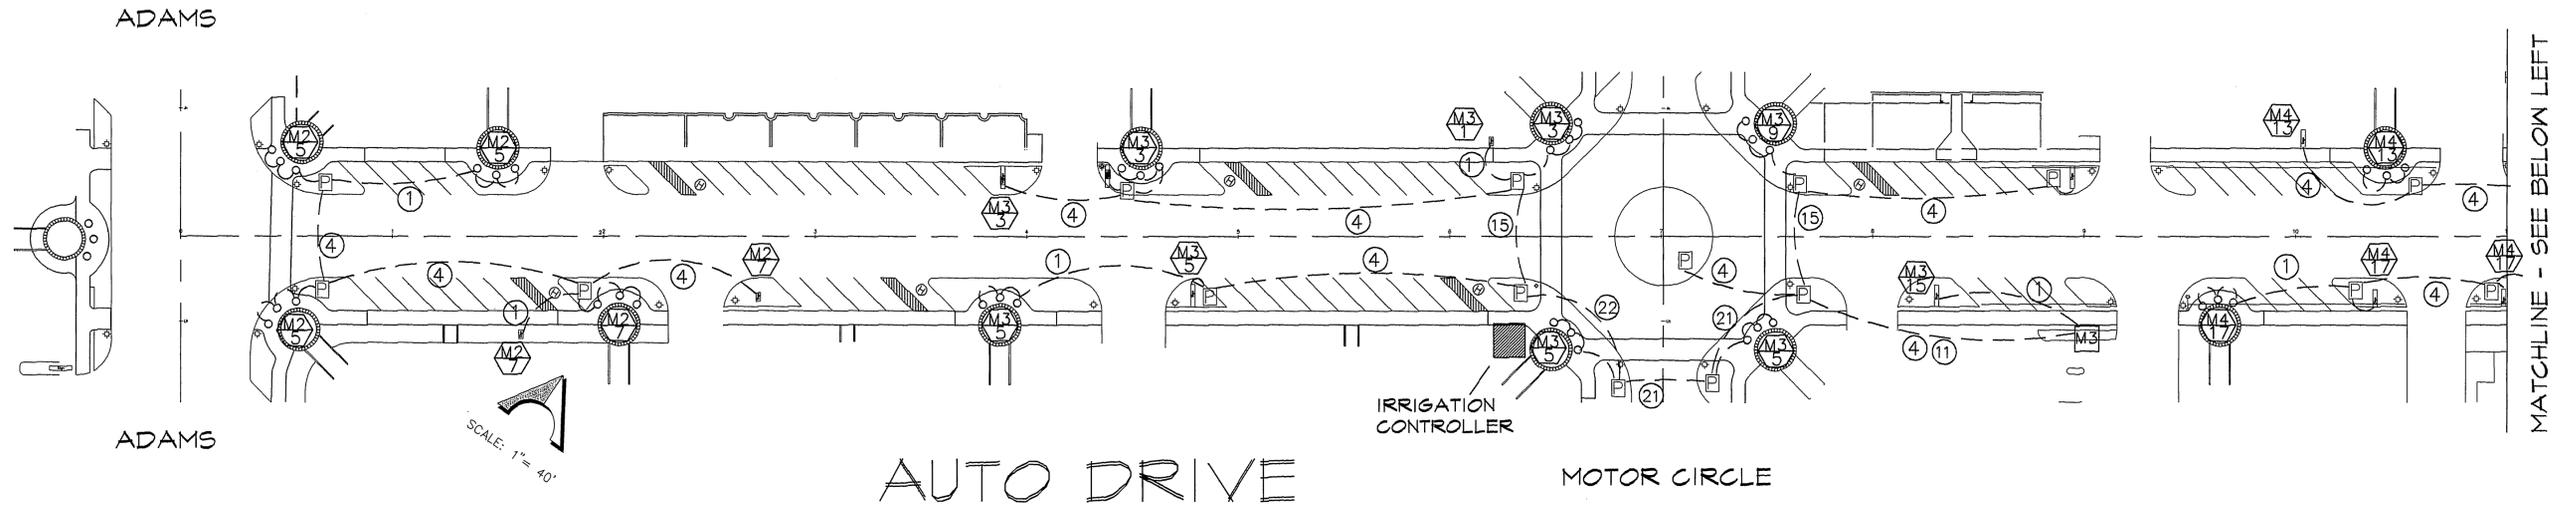

REMOVE AND RELOCATE LIGHT STANDARD TO NEW LOCATION BEHIND NEW CURB. SEE STREET LIGHT SPECIFICATION 2-6 & U65 800 & 801.

C:\AUTOMALL\3380SGN1 Med Oct 22 14:13:01 1997

Underground Service Alert
Call: TOLL FREE
1 - 800
422 - 4133
TWO WORKING DAYS BEFORE YOU DIG

PRIVATE ENGINEERING NOTE
CONSTRUCTION CONTRACTOR AGREES THAT IN ACCORDANCE WITH GENERALLY ACCEPTED CONSTRUCTION PRACTICES, CONSTRUCTION CONTRACTOR SHALL BE REQUIRED TO ASSUME SOLE AND COMPLETE RESPONSIBILITY FOR ALL SITE CONDITIONS DURING THE COURSE OF CONSTRUCTION OF THE PROJECT, INCLUDING SAFETY OF ALL PERSONS AND PROPERTY. THAT THIS REQUIREMENT SHALL BE MADE TO APPLY CONTINUOUSLY AND NOT BE LIMITED TO NORMAL WORKING HOURS, AND CONSTRUCTION CONTRACTOR FURTHER AGREES TO DEFEND, INDEMNIFY AND HOLD DESIGN PROFESSIONAL HARMLESS FROM ANY AND ALL LIABILITY, REAL OR ALLEGED, IN CONNECTION WITH THE PERFORMANCE OF WORK ON THIS PROJECT, EXCEPTING LIABILITY ARISING FROM THE SOLE NEGLIGENCE OF DESIGN PROFESSIONAL.



WEST COAST DESIGN
ELECTRICAL AND LIGHTING ENGINEERS
26692 PASEO BRILLO, SUITE 200
SAN JUAN CAPISTRANO, CA 92675
(714) 240-1978 FAX 240-1782

J.F. DAVIDSON ASSOCIATES, INC.
- CIVIL ENGINEERS - SURVEYORS - PLANNERS -
1777 ATLANTA ST., STE. G-5 RIVERSIDE, CA 92507
(909) 948-8844 FAX 909-998-5854

27349 JEFFERSON ST. TEMECULA, CA 92290
(909) 678-7710 FAX 909-698-1981
75-110 SHERYL AVE. STE D PALM DESERT, CA 92260
(619) 346-2510 FAX (619) 346-7772

SCALE: 1"=40'
DATE: APRIL 18, 1997
BENCH MARK: RIV. CO. BM 601-21-68, CALTRANS BRASS DISK SET IN CONC. WELL LOCATED IN CENTERLINE OF MONROE STREET 40' NW OF INDIANA AVENUE ELEVATION: 810.933

MARK	REVISIONS	APPR.	DATE
DESIGNED BY	RO	DRAWN BY	RO
CHECKED BY	RN		


CITY OF RIVERSIDE, DEPARTMENT OF PUBLIC WORKS

APPROVED BY	BY	DATE	APPROVED BY
PRINCIPAL ENGR.			DIRECTOR OF PUBLIC WORKS
PARK DEPARTMENT			
TRAFFIC DIVISION			
CHIEF P.W. ENGR.			

IN THE CITY OF RIVERSIDE, COUNTY OF RIVERSIDE STATE OF CALIFORNIA
AUTO CENTER RENOVATION PLAN
SIGN LIGHTING PLAN
AUTO DRIVE
FOR: RIVERSIDE AUTO CENTER ASSESSMENT DISTRICT

STREET LIGHTING
R-3471
SHEET **E3** OF 10
FILE NO.: 9613380

INDEXED 12-26-01 (4H)

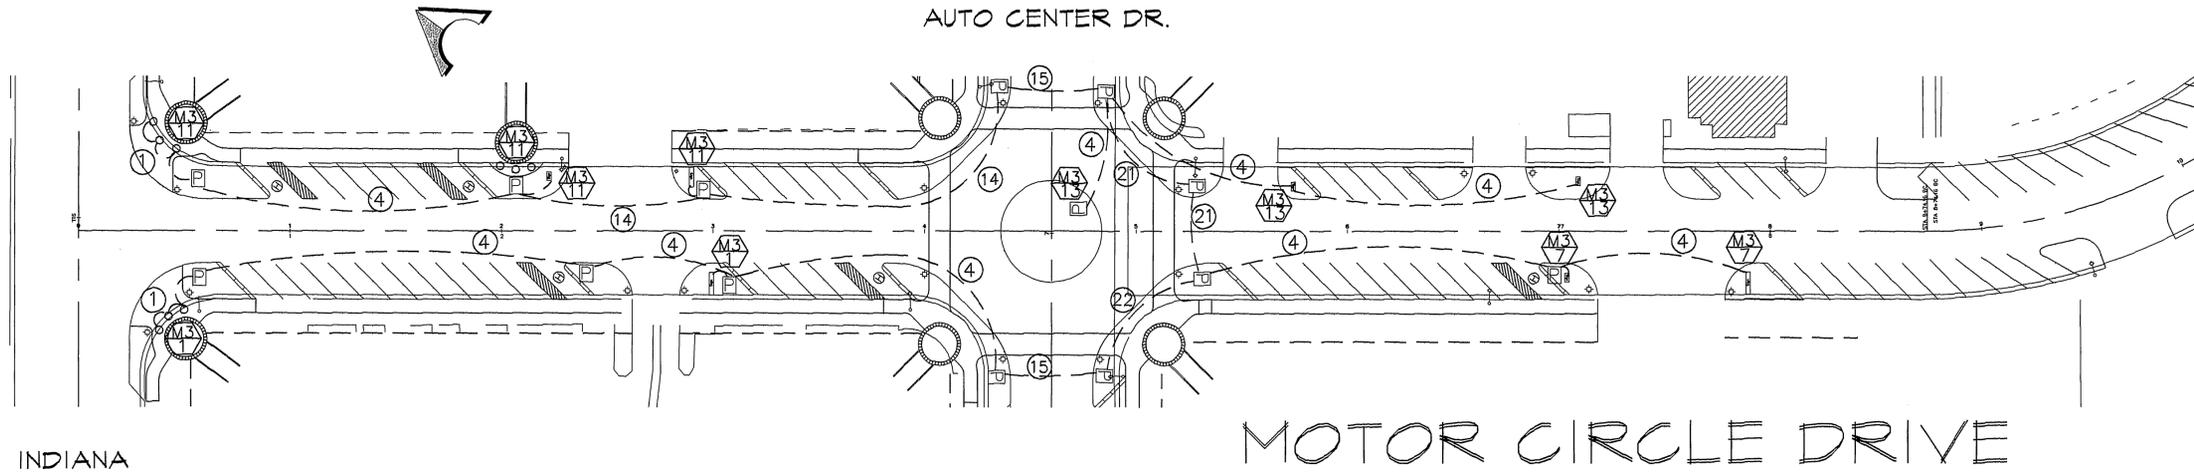


MATCHLINE - SEE BELOW LEFT

INDIANA

MOTOR CIRCLE DRIVE


MATCHLINE - SEE ABOVE RIGHT

MATCHLINE - SEE BELOW LEFT

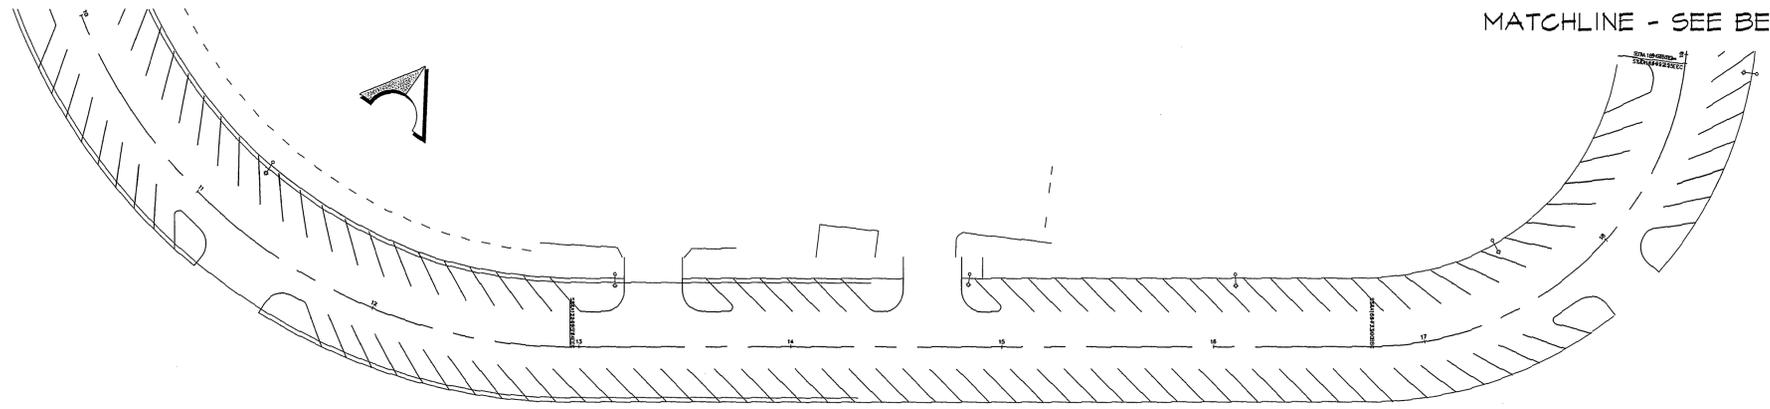

1

MATCHLINE - SEE ABOVE RIGHT

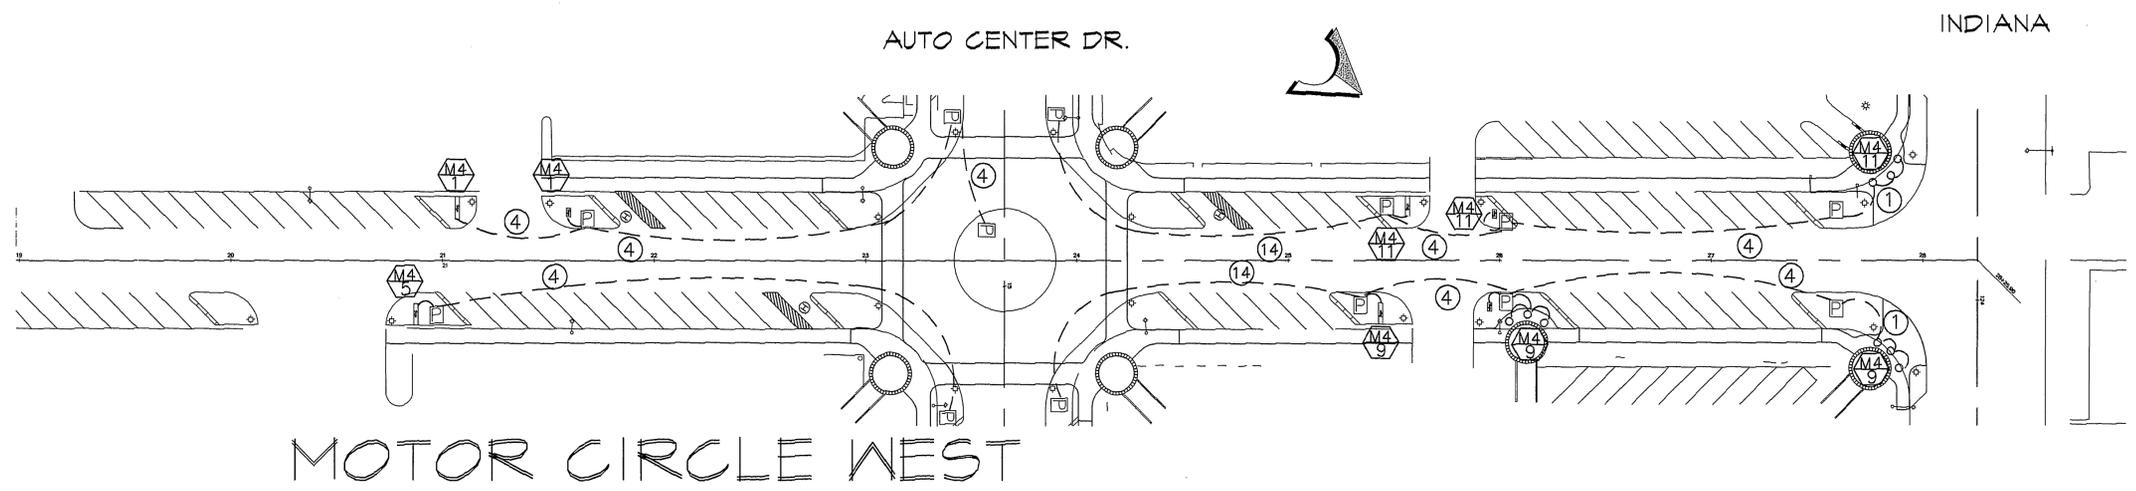


INDIANA

MOTOR CIRCLE WEST

C:\AUTOMALL\3380SON2 Med Oct 22 14:57:25 1997

Underground Service Alert
Call: TOLL FREE
1 - 800
422 - 4133
TWO WORKING DAYS BEFORE YOU DIG

PRIVATE ENGINEERING NOTE
CONSTRUCTION CONTRACTOR AGREES THAT IN ACCORDANCE WITH GENERALLY ACCEPTED CONSTRUCTION PRACTICES, CONSTRUCTION CONTRACTOR WILL BE REQUIRED TO ASSUME SOLE AND COMPLETE RESPONSIBILITY FOR JOB SITE CONDITIONS DURING THE COURSE OF CONSTRUCTION OF THE PROJECT, INCLUDING SAFETY OF ALL PERSONS CONTINUOUSLY AND NOT BE LIMITED TO NORMAL WORKING HOURS, AND CONSTRUCTION CONTRACTOR FURTHER AGREES TO DEFEND, INDEMNIFY AND HOLD DESIGN PROFESSIONAL HARMLESS FROM ANY AND ALL LIABILITY, REAL OR ALLEGED, IN CONNECTION WITH THE PERFORMANCE OF WORK ON THIS PROJECT, EXCEPTING LIABILITY ARISING FROM THE SOLE NEGLIGENCE OF DESIGN PROFESSIONAL.

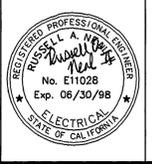

WEST COAST DESIGN
ELECTRICAL AND LIGHTING ENGINEERS
26692 PASO DELLO, SUITE 200
SAN JUAN CAPISTRANO, CA 92675
(714) 240-1978 FAX 240-1782

J.F. DAVIDSON ASSOCIATES, INC.
- CIVIL ENGINEERS - SURVEYORS - PLANNERS -
1777 ATLANTA ST., STE. 0-5 RIVERSIDE, CA 92507 (909) 956-0844 FAX 909-686-5954
27349 JEFFERSON ST. TEMECULA, CA 92390 (909) 678-7710 FAX 909-699-1981
75-150 SHERYL AVE. STE.D PALM DESERT, CA 92260 (818) 346-2510 FAX (818) 346-7772

SCALE: 1" = 40'
BENCH MARK: RIV. CO. BM 601-21-6B, CALTRANS BRASS DISK SET IN CONC. WELL LOCATED IN CENTERLINE OF MONROE STREET 40' NW OF INDIANA AVENUE ELEVATION: 810.933
DATE: OCTOBER 1997

ADDED SIGNS @ CAR WASH	
MARK	REVISIONS
DESIGNED BY: RO	DRAWN BY: RO
CHECKED BY: RN	DATE:


CITY OF RIVERSIDE, DEPARTMENT OF PUBLIC WORKS			
APPROVED BY	BY	DATE	APPROVED BY
PRINCIPAL ENGR.			DIRECTOR OF PUBLIC WORKS
PARK DEPARTMENT			DATE
TRAFFIC DIVISION			
CHIEF P.W. ENGR.			

IN THE CITY OF RIVERSIDE, COUNTY OF RIVERSIDE STATE OF CALIFORNIA
AUTO CENTER RENOVATION PLAN
SIGN LIGHTING PLAN
MOTOR CIRCLE DRIVE
FOR: RIVERSIDE AUTO CENTER ASSESSMENT DISTRICT

STREET LIGHTING
R-3471
SHEET E5 OF 10
FILE NO.: 9613380

INDEXED 12-26-01 LHM

AUTO CENTER DR.

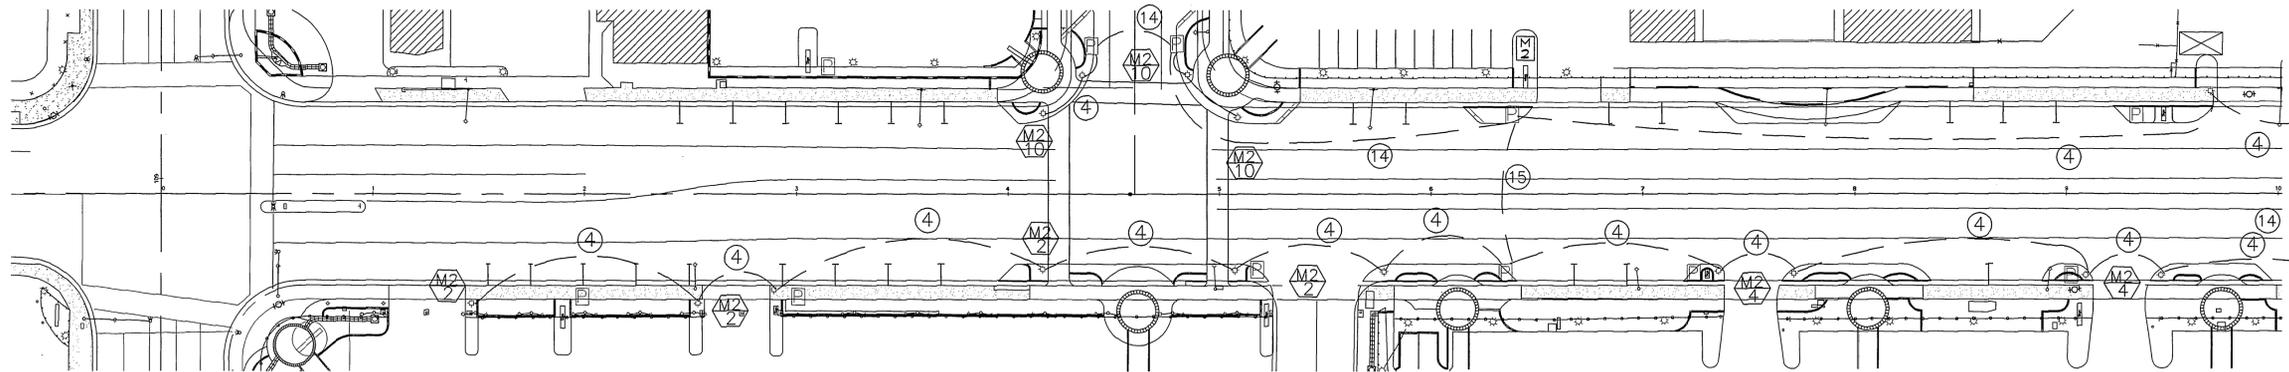


MATCHLINE - SEE BELOW LEFT

INDIANA


ADAMS



MATCHLINE - SEE ABOVE RIGHT

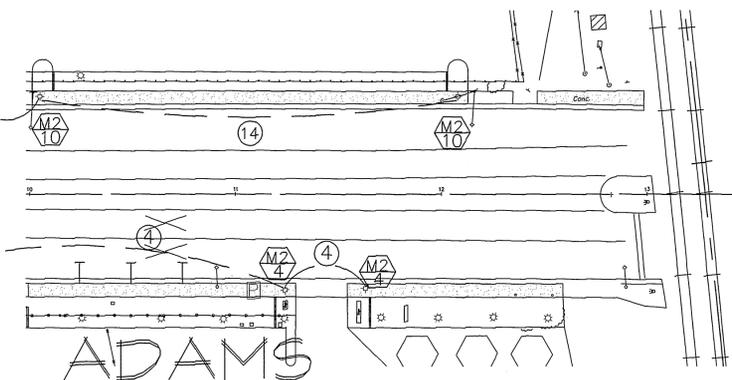


ADAMS

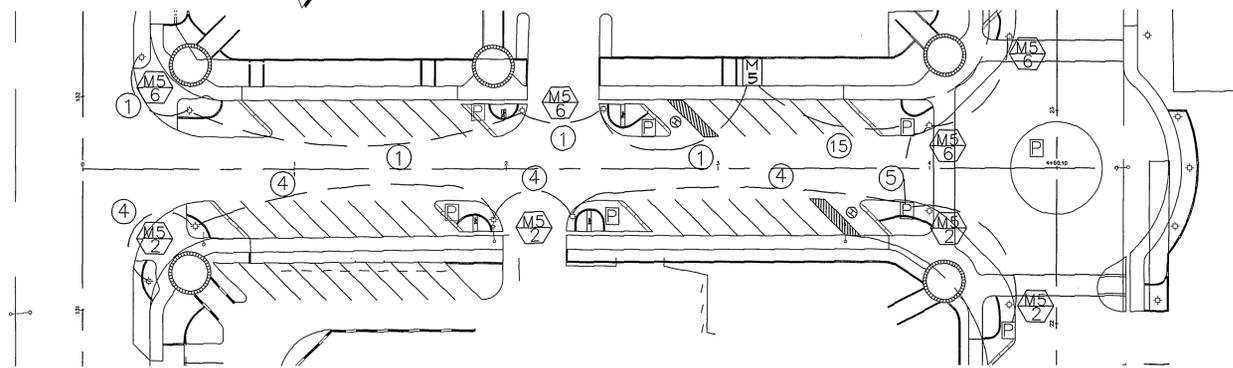

INDIANA

DETROIT

AUTO CENTER DR.

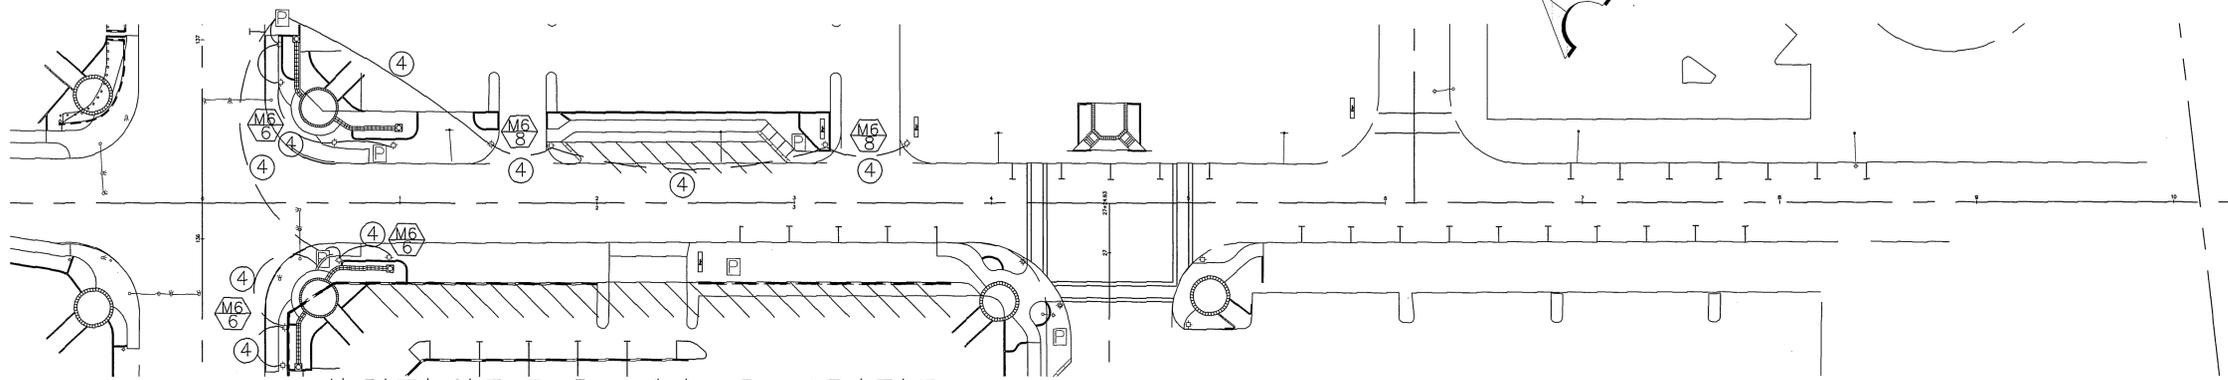

INDIANA


JEFFERSON STREET

AUTO CENTER DR.


C:\AUTOMALL\33805GN3 Tue Jun 10 13:39:03 1997

<p>Underground Service Alert Call: TOLL FREE 1 - 800 422 - 4133 TWO WORKING DAYS BEFORE YOU DIG</p>	<p>PRIVATE ENGINEERING NOTE</p> <p>CONSTRUCTION CONTRACTOR AGREES THAT IN ACCORDANCE WITH GENERALLY ACCEPTED CONSTRUCTION PRACTICES, CONSTRUCTION CONTRACTOR WILL BE REQUIRED TO ASSUME SOLE AND COMPLETE RESPONSIBILITY FOR ALL SITE CONDITIONS DURING THE COURSE OF CONSTRUCTION OF THE PROJECT, INCLUDING SAFETY OF ALL PERSONS AND PROPERTY. THAT THIS REQUIREMENT SHALL BE MADE TO APPLY CONTINUOUSLY AND NOT BE LIMITED TO NORMAL WORKING HOURS, AND CONSTRUCTION CONTRACTOR FURTHER AGREES TO DEFEND, INDEMNIFY AND HOLD DESIGN PROFESSIONAL HARMLESS FROM ANY AND ALL LIABILITY, REAL OR ALLEGED, IN CONNECTION WITH THE PERFORMANCE OF WORK ON THIS PROJECT, EXCEPTING LIABILITY ARISING FROM THE SOLE NEGLIGENCE OF DESIGN PROFESSIONAL.</p>		<p>WEST COAST DESIGN ELECTRICAL AND LIGHTING ENGINEERS 26692 PASEO BRILLO, SUITE 200 SAN JUAN CAPISTRANO, CA 92675 (714) 240-1578 FAX 240-1782</p>	<p>J.F. DAVIDSON ASSOCIATES, INC. - CIVIL ENGINEERS - SURVEYORS - PLANNERS - 1777 ATLANTA ST., STE. G-5 RIVERSIDE, CA 92507 (909) 686-0844 FAX 909-686-5954 27349 JEFFERSON ST. TEMESCUA, CA 92390 (909) 776-7710 FAX 909-699-1981 75-150 SHERYL AVE. STE. D PALM DESERT, CA 92260 (619) 346-2510 FAX (619) 346-7772</p>	<p>CITY OF RIVERSIDE, DEPARTMENT OF PUBLIC WORKS</p> <table border="1"> <tr> <td>APPROVED BY</td> <td>BY</td> <td>DATE</td> <td>APPROVED BY</td> </tr> <tr> <td>PRINCIPAL ENGR.</td> <td></td> <td></td> <td>DIRECTOR OF PUBLIC WORKS</td> </tr> <tr> <td>PARK DEPARTMENT</td> <td></td> <td></td> <td></td> </tr> <tr> <td>TRAFFIC DIVISION</td> <td></td> <td></td> <td></td> </tr> <tr> <td>CHIEF P.W. ENGR.</td> <td></td> <td></td> <td></td> </tr> </table>	APPROVED BY	BY	DATE	APPROVED BY	PRINCIPAL ENGR.			DIRECTOR OF PUBLIC WORKS	PARK DEPARTMENT				TRAFFIC DIVISION				CHIEF P.W. ENGR.				<p>IN THE CITY OF RIVERSIDE, COUNTY OF RIVERSIDE STATE OF CALIFORNIA</p> <p>AUTO CENTER RENOVATION PLAN</p> <p>STREET LIGHTING PLAN ADAMS STREET, DETROIT DRIVE JEFFERSON AVENUE</p> <p>FOR: RIVERSIDE AUTO CENTER ASSESSMENT DISTRICT</p>	<p>STREET LIGHTING</p> <p>R-3471</p> <p>SHEET E6 OF 10</p> <p>FILE NO.: 9613380</p>
						APPROVED BY	BY	DATE	APPROVED BY																		
PRINCIPAL ENGR.			DIRECTOR OF PUBLIC WORKS																								
PARK DEPARTMENT																											
TRAFFIC DIVISION																											
CHIEF P.W. ENGR.																											
<p>SCALE: 1" = 40'</p> <p>DATE: MARCH 1997</p>	<p>BENCH MARK: RIV. CO. BM 601-21-68, CALTRANS BRASS DISK SET IN CONC. WELL LOCATED IN CENTERLINE OF MONROE STREET 40' NW OF INDIANA AVENUE ELEVATION: 810.933</p>	<p>MARK</p> <p>DESIGNED BY: RO</p>	<p>REVISIONS</p> <p>DRAWN BY: RO</p>	<p>APPR. DATE</p> <p>CHECKED BY: RN</p>																							


INDEXED 12-26-01 LKH

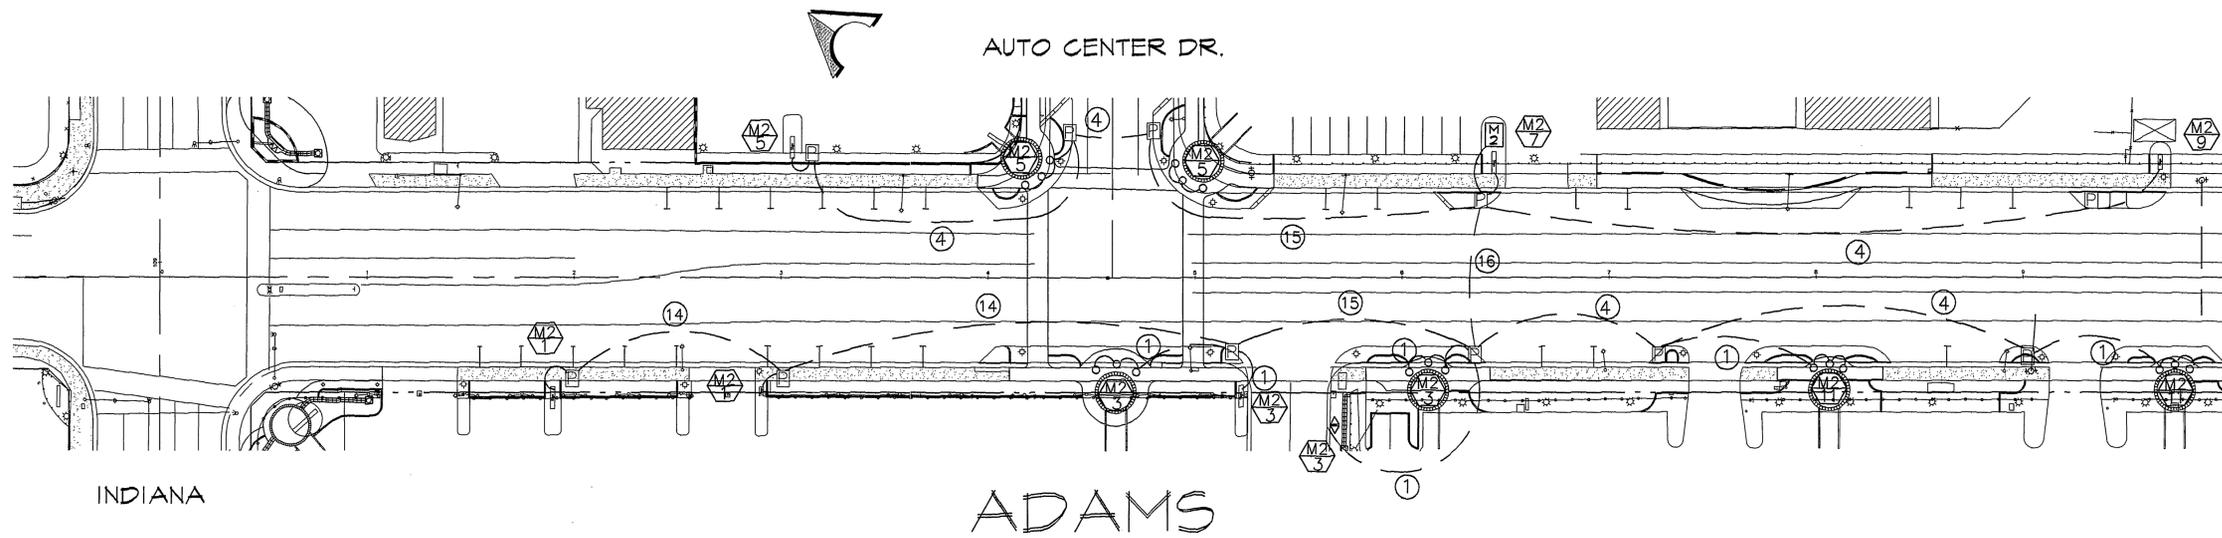

MATCHLINE - SEE BELOW LEFT

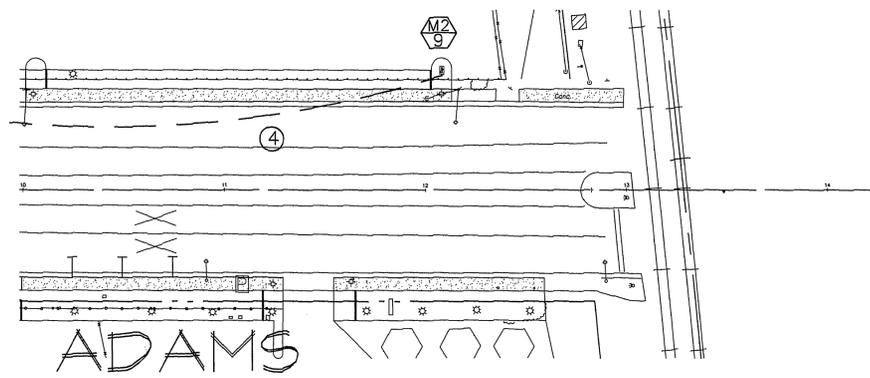


MATCHLINE - SEE ABOVE RIGHT

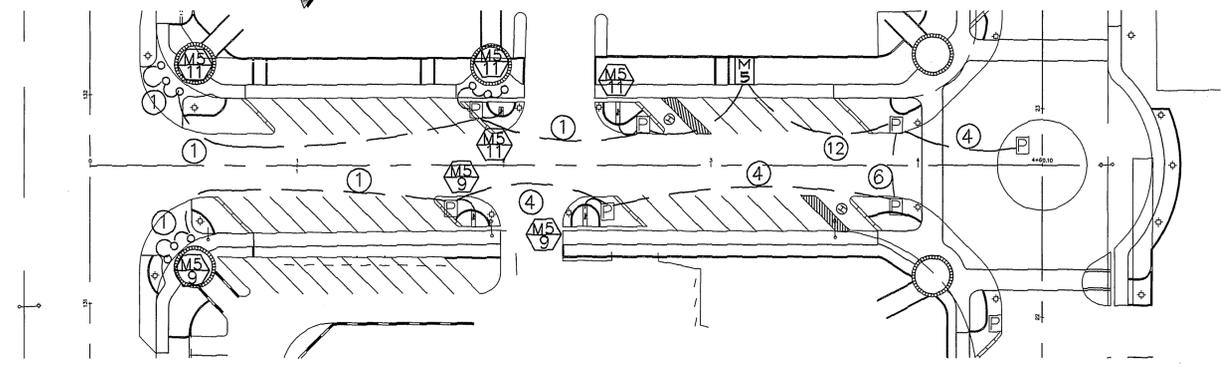

INDIANA

DETROIT

AUTO CENTER DR.

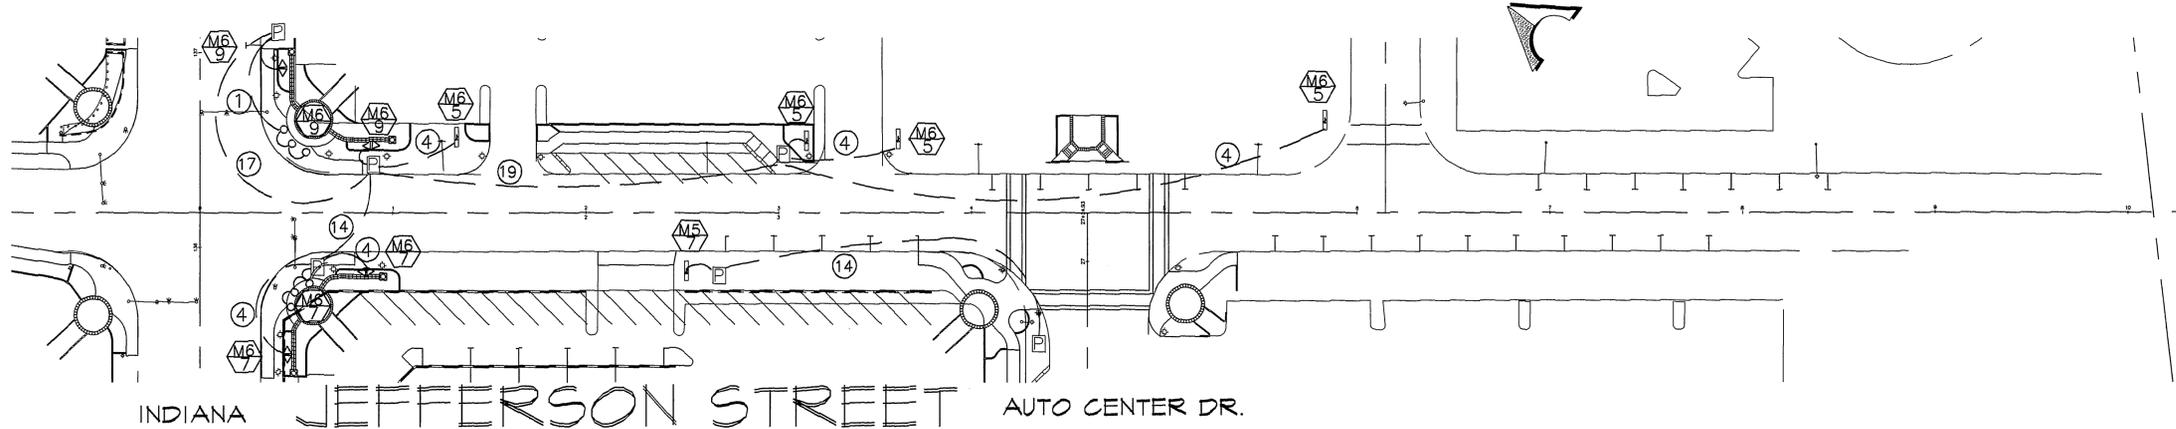

INDIANA


JEFFERSON STREET

AUTO CENTER DR.


C:\AUTOMALL\3380SGN3 Wed Oct 22 15:43:45 1997

<p>Underground Service Alert Call: TOLL FREE 1 - 800 422 - 4133 TWO WORKING DAYS BEFORE YOU DIG</p>	<p>PRIVATE ENGINEERING NOTE CONSTRUCTION CONTRACTOR AGREES THAT IN ACCORDANCE WITH GENERALLY ACCEPTED CONSTRUCTION PRACTICES, CONSTRUCTION CONTRACTOR WILL BE REQUIRED TO ASSUME SOLE AND COMPLETE RESPONSIBILITY FOR JOB SITE CONDITIONS DURING THE COURSE OF CONSTRUCTION OF THE PROJECT, INCLUDING SAFETY OF ALL PERSONS AND PROPERTY. THAT THIS REQUIREMENT SHALL BE MADE TO APPLY CONTINUOUSLY AND NOT BE LIMITED TO NORMAL WORKING HOURS, AND CONSTRUCTION CONTRACTOR FURTHER AGREES TO DEFEND, HOLD HARMLESS AND HOLD DESIGN PROFESSIONAL LIABILITY FREE FROM ANY AND ALL LIABILITY OF DESIGN PROFESSIONAL IN CONNECTION WITH THE PERFORMANCE OF WORK ON THE PROJECT, EXCEPT LIABILITY ARISING FROM THE SOLE NEGLIGENCE OF DESIGN PROFESSIONAL.</p>	<p>WEST COAST DESIGN ELECTRICAL AND LIGHTING ENGINEERS 26692 PASEO PRILLO, SUITE 200 SAN JUAN CAPISTRANO, CA 92675 (714) 240-1878 FAX 240-1782</p>	<p>J.F. DAVIDSON ASSOCIATES, INC. - CIVIL ENGINEERS - SURVEYORS - PLANNERS - 1777 ATLANTA ST., STE. 0-5 RIVERSIDE, CA 92507 (951) 952-0844 FAX 951-952-5954 27349 JEFFERSON ST. TEMECULA, CA 92590 (951) 776-7710 FAX 951-699-1981 75-150 SHERIDAN AVE. STE. D PALM DESERT, CA 92260 (619) 246-2510 FAX (619) 346-7772</p>	<p>RELOCATED SIGNS</p>	<p>CITY OF RIVERSIDE, DEPARTMENT OF PUBLIC WORKS</p>		<p>IN THE CITY OF RIVERSIDE, COUNTY OF RIVERSIDE STATE OF CALIFORNIA AUTO CENTER RENOVATION PLAN SIGN LIGHTING PLAN ADAMS STREET, DETROIT DRIVE JEFFERSON AVENUE</p>	<p>STREET LIGHTING R-3471 SHEET E7 OF 10 FOR: RIVERSIDE AUTO CENTER ASSESSMENT DISTRICT FILE NO.: 9613380</p>
					<p>SCALE: 1" = 40' DATE: OCTOBER 1997</p>	<p>BENCH MARK: RIV. CO. BM 601-21-68, CALTRANS BRASS DISK SET IN CONC. WELL LOCATED IN CENTERLINE OF MONROE STREET 40' NW OF INDIANA AVENUE ELEVATION: 810.933</p>		


INDEXED 12-26-01

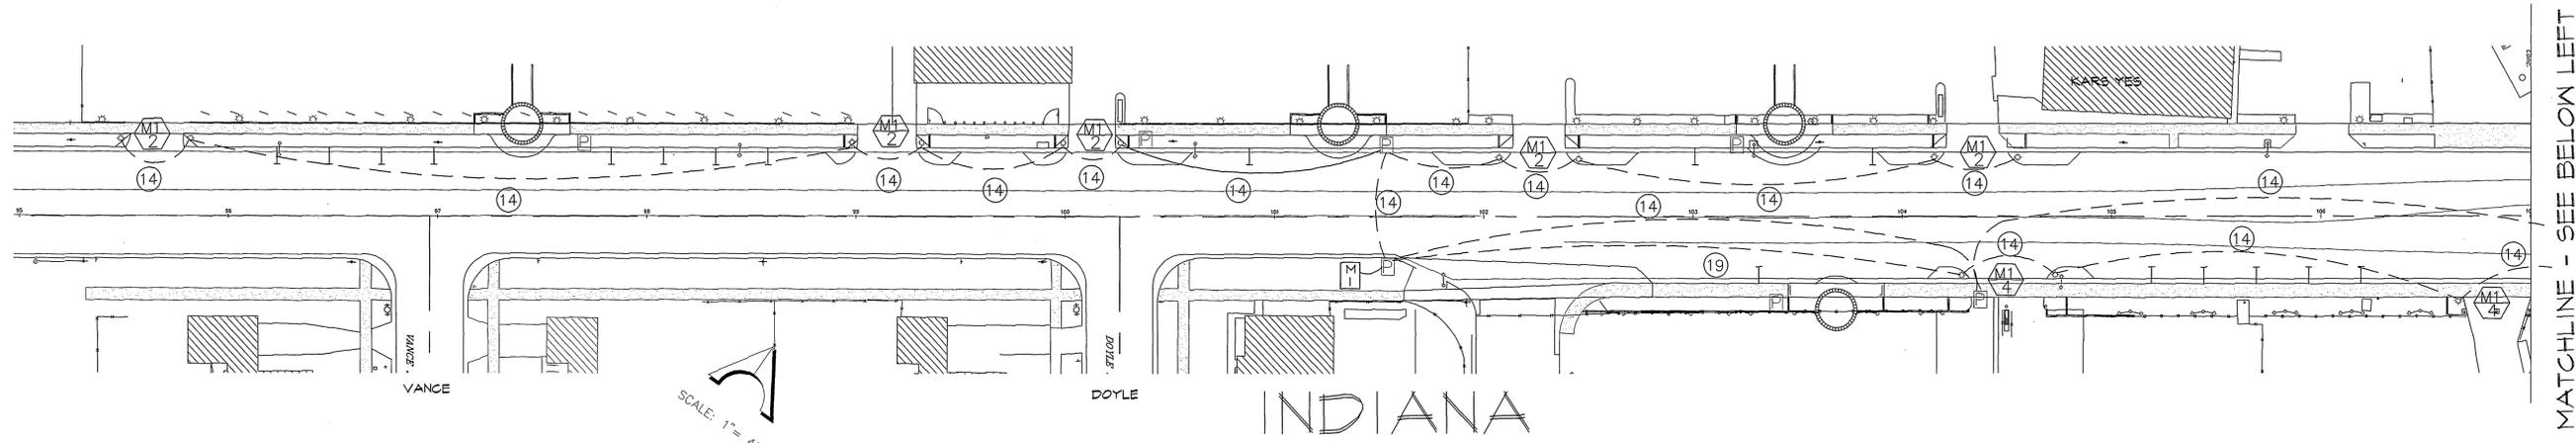


MATCHLINE - SEE BELOW LEFT

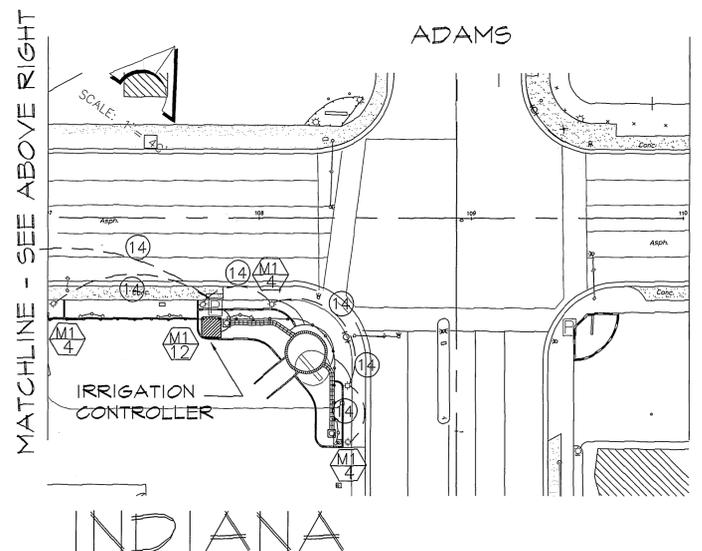

MATCHLINE - SEE ABOVE RIGHT

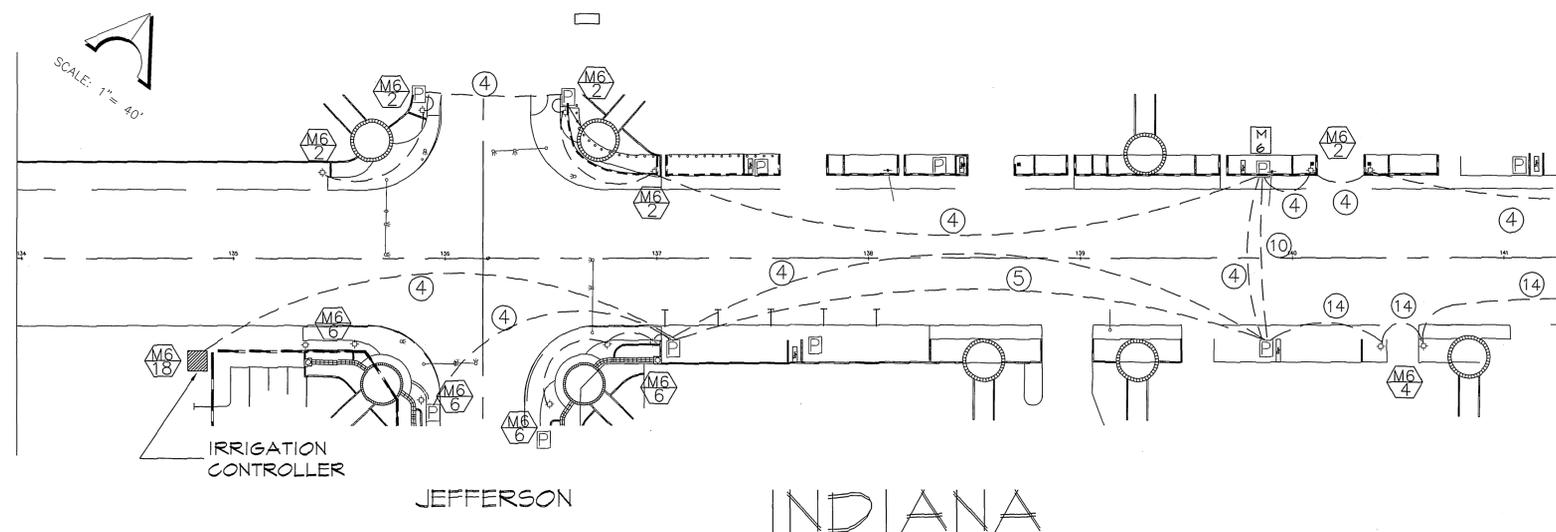

MATCHLINE - SEE BELOW LEFT

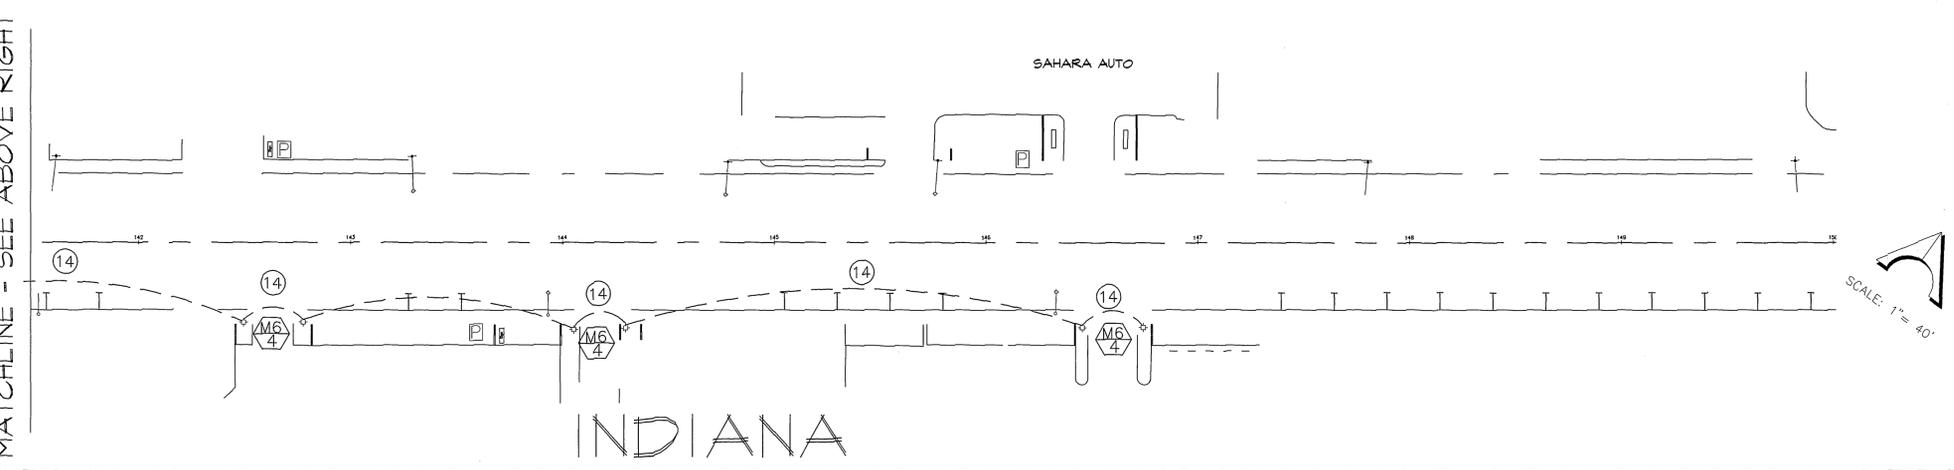

MATCHLINE - SEE ABOVE RIGHT

C:\AUTOMALL\3380SON4 Mon Jun 16 10:13:30 1997

Underground Service Alert
Call: TOLL FREE
1 - 800
422 - 4133
TWO WORKING DAYS BEFORE YOU DIG

PRIVATE ENGINEERING NOTE
CONSTRUCTION CONTRACTOR AGREES THAT IN ACCORDANCE WITH GENERALLY ACCEPTED CONSTRUCTION PRACTICES, CONSTRUCTION CONTRACTOR WILL BE REQUIRED TO ASSUME SOLE AND COMPLETE RESPONSIBILITY FOR JOB SITE CONDITIONS DURING THE COURSE OF CONSTRUCTION OF THE PROJECT, INCLUDING SAFETY OF ALL PERSONS AND PROPERTY, THAT THIS REQUIREMENT SHALL BE MADE TO APPLY CONTINUOUSLY AND NOT BE LIMITED TO NORMAL WORKING HOURS, AND CONSTRUCTION CONTRACTOR FURTHER AGREES TO DEFEND, INDEMNIFY AND HOLD DESIGN PROFESSIONAL HARMLESS FROM ANY AND ALL LIABILITY, REAL OR ALLEGED, IN CONNECTION WITH THE PERFORMANCE OF WORK ON THIS PROJECT, EXCEPTING LIABILITY ARISING FROM THE SOLE NEGLIGENCE OF DESIGN PROFESSIONAL.



WEST COAST DESIGN
ELECTRICAL AND LIGHTING ENGINEERS
26692 PASEO BRILLO, SUITE 200
SAN JUAN CAPISTRANO, CA 92675
(714) 240-1878 FAX 240-1782

J.F. DAVIDSON ASSOCIATES, INC.
- CIVIL ENGINEERS - SURVEYORS - PLANNERS -
1777 ATLANTA ST., STE. G-5 RIVERSIDE, CA 92507 (909)886-8844 FAX 909-886-5954
22349 JEFFERSON ST. TEMECULA, CA 92390 (909)976-7770 FAX 909-699-1981
75-150 SHERYL AVE. STE D PALM DESERT, CA 92260 (619)346-2510 FAX (619)346-7772

SCALE: 1"=40'
BENCH MARK: RIV. CO. BM 601-21-6B, CALTRANS BRASS DISK SET IN CONC. WELL LOCATED IN CENTERLINE OF MONROE STREET 40' NW OF INDIANA AVENUE ELEVATION: 810.933
DATE: MARCH 1997

MARK	REVISIONS	APPR. DATE
RO	DESIGNED BY	
RO	DRAWN BY	
RN	CHECKED BY	


CITY OF RIVERSIDE, DEPARTMENT OF PUBLIC WORKS

APPROVED BY	BY	DATE	APPROVED BY
PRINCIPAL ENGR.			DIRECTOR OF PUBLIC WORKS
PARK DEPARTMENT			
TRAFFIC DIVISION			
CHIEF P.W. ENGR.			

IN THE CITY OF RIVERSIDE, COUNTY OF RIVERSIDE STATE OF CALIFORNIA
AUTO CENTER RENOVATION PLAN
STREET LIGHTING PLAN
INDIANA AVENUE
FOR: RIVERSIDE AUTO CENTER ASSESSMENT DISTRICT

STREET LIGHTING
R-3471
SHEET **E8** OF 10
FILE NO.: 9618380


INDEXED 12-26-01 LPH

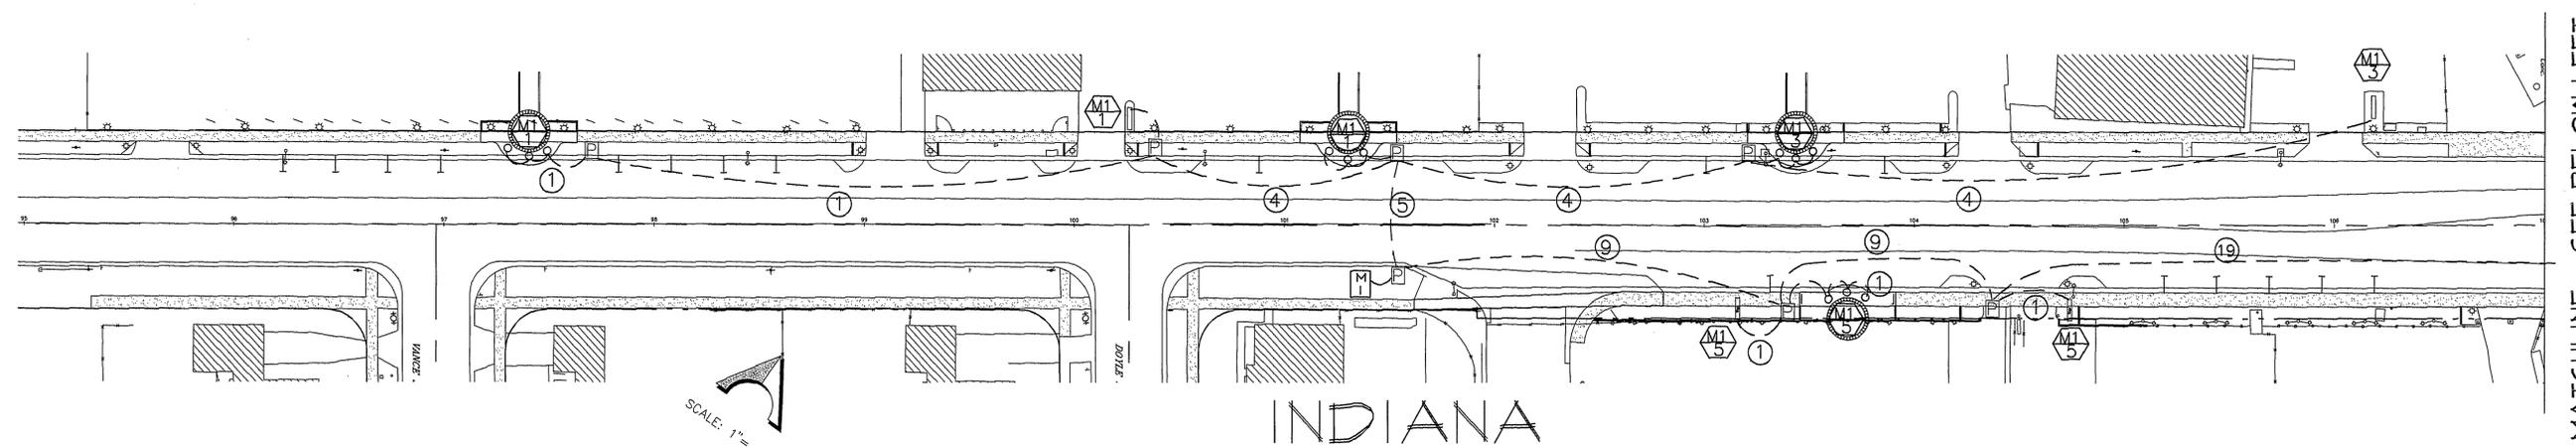

MATCHLINE - SEE BELOW LEFT

INDIANA


FEED FROM PANEL IN DEALERSHIP. INSTALL IN JOINT TRENCH WITH CONDUIT FOR DEALER LIGHTING (SEE SHEET DL-7) USE RELAYS TO CONTROL SIGN.

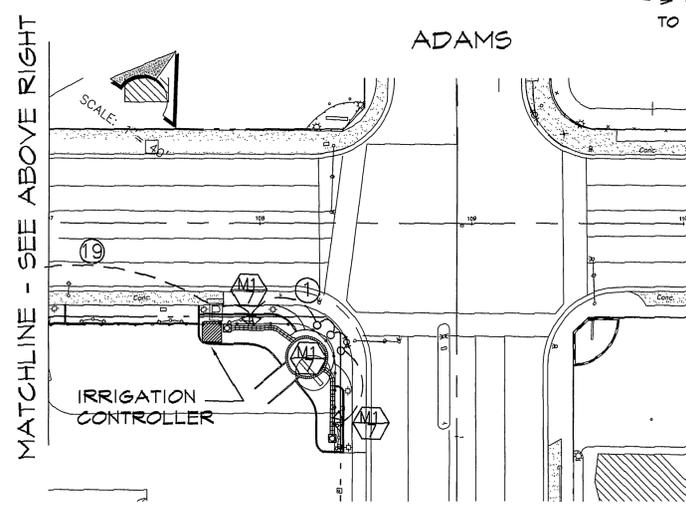

ADAMS

MATCHLINE - SEE ABOVE RIGHT


INDIANA

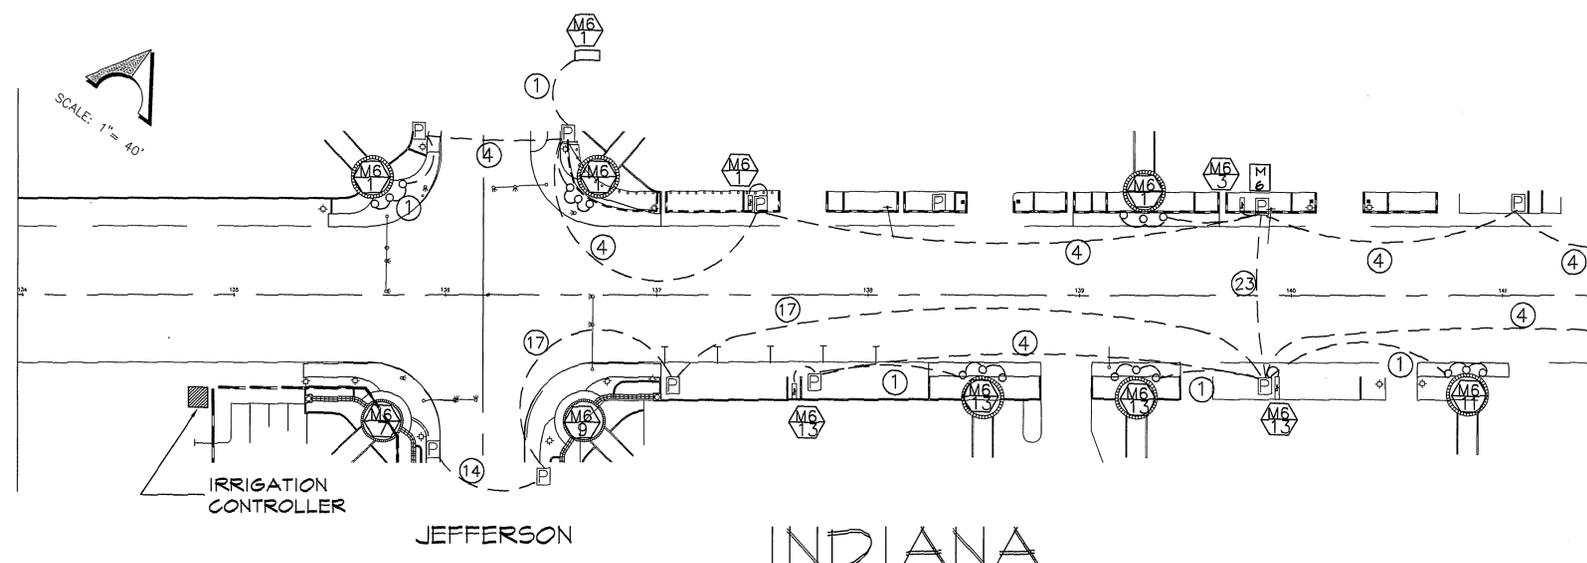

JEFFERSON

INDIANA

MATCHLINE - SEE BELOW LEFT

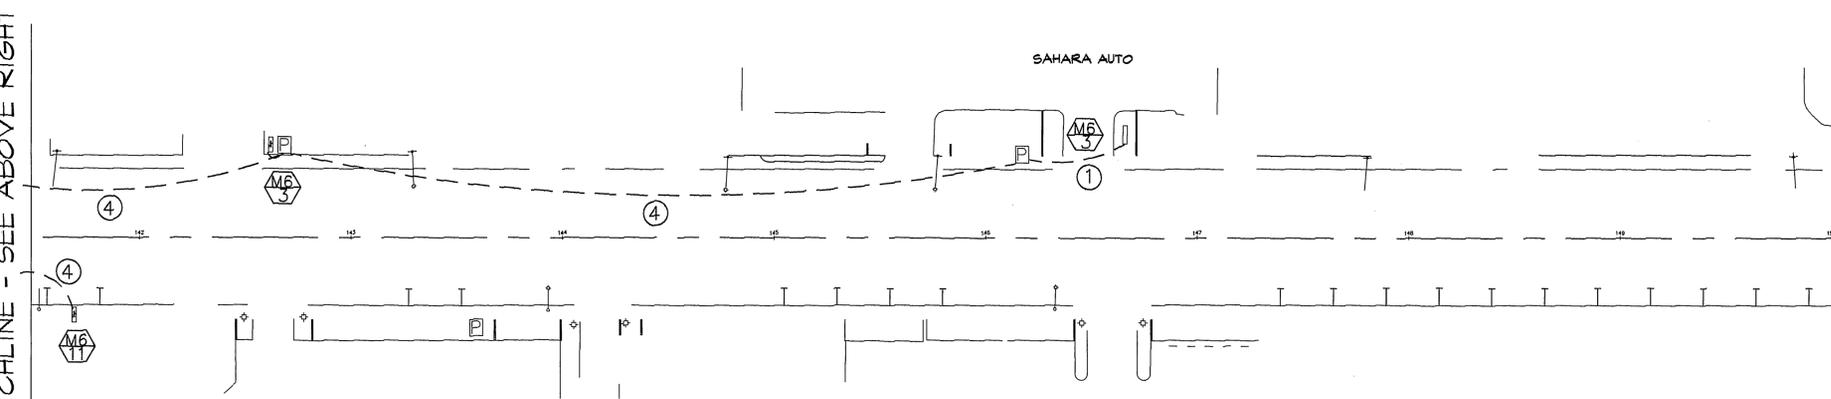

SAHARA AUTO

INDIANA

MATCHLINE - SEE ABOVE RIGHT

C:\AUTOMALL\3380SON4 Thu Oct 23 12:53:17 1997

<p>Underground Service Alert Call: TOLL FREE 1 - 800 422 - 4133 TWO WORKING DAYS BEFORE YOU DIG</p>	<p>PRIVATE ENGINEERING NOTE</p> <p>CONSTRUCTION CONTRACTOR AGREES THAT IN ACCORDANCE WITH GENERALLY ACCEPTED CONSTRUCTION PRACTICES, CONSTRUCTION CONTRACTOR WILL BE REQUIRED TO ASSUME SOLE AND COMPLETE RESPONSIBILITY FOR THE SITE CONDITIONS DURING THE COURSE OF CONSTRUCTION OF THE PROJECT, INCLUDING SAFETY OF ALL PERSONS AND PROPERTY, THAT THIS REQUIREMENT SHALL BE MADE TO APPLY CONTINUOUSLY AND NOT BE LIMITED TO NORMAL WORKING HOURS, AND CONSTRUCTION CONTRACTOR FURTHER AGREES TO DEFEND, INDEMNIFY AND HOLD DESIGN PROFESSIONAL FIRMLESS FROM ANY AND ALL LIABILITY, REAL OR ALLEGED, IN CONNECTION WITH THE PERFORMANCE OF WORK ON THIS PROJECT EXCEPTING LIABILITY ARISING FROM THE SOLE NEGLIGENCE OF DESIGN PROFESSIONAL.</p>		<p>WEST COAST DESIGN ELECTRICAL AND LIGHTING ENGINEERS 26692 PASEO BRILLO, SUITE 200 SAN JUAN CAPISTRANO, CA 92675 (714) 240-1978 FAX 240-1782</p>	<p>J.F. DAVIDSON ASSOCIATES, INC. - CIVIL ENGINEERS - SURVEYORS - PLANNERS - 1777 ATLANTA ST., STE. G-5 RIVERSIDE, CA 92507 (909) 956-0844 FAX 909-666-5954 27349 JEFFERSON ST. TEMECULA, CA 92590 (909) 976-7710 FAX 909-699-1981 75-150 SHERYL AVE. STE D PALM DESERT, CA 92260 (619) 346-2210 FAX (619) 346-7772</p>	<p>CITY OF RIVERSIDE, DEPARTMENT OF PUBLIC WORKS</p> <table border="1" style="width: 100%; border-collapse: collapse;"> <tr> <td>APPROVED BY</td> <td>BY</td> <td>DATE</td> <td>APPROVED BY</td> </tr> <tr> <td>PRINCIPAL ENGR.</td> <td></td> <td></td> <td>DIRECTOR OF PUBLIC WORKS</td> </tr> <tr> <td>PARK DEPARTMENT</td> <td></td> <td></td> <td></td> </tr> <tr> <td>TRAFFIC DIVISION</td> <td></td> <td></td> <td></td> </tr> <tr> <td>CHIEF P.W. ENGR.</td> <td></td> <td></td> <td></td> </tr> </table>	APPROVED BY	BY	DATE	APPROVED BY	PRINCIPAL ENGR.			DIRECTOR OF PUBLIC WORKS	PARK DEPARTMENT				TRAFFIC DIVISION				CHIEF P.W. ENGR.				<p>IN THE CITY OF RIVERSIDE, COUNTY OF RIVERSIDE STATE OF CALIFORNIA</p> <p>AUTO CENTER RENOVATION PLAN</p> <p>SIGN LIGHTING PLAN</p> <p>INDIANA AVENUE</p> <p>FOR: RIVERSIDE AUTO CENTER ASSESSMENT DISTRICT</p>	<p>STREET LIGHTING</p> <p>R-3471</p> <p>SHEET E9 OF 10</p> <p>FILE NO.: 9613380</p>
APPROVED BY	BY	DATE	APPROVED BY																								
PRINCIPAL ENGR.			DIRECTOR OF PUBLIC WORKS																								
PARK DEPARTMENT																											
TRAFFIC DIVISION																											
CHIEF P.W. ENGR.																											
		<p>SCALE: 1"=40'</p> <p>DATE: OCTOBER 1997</p>		<p>MARK REVISIONS APPR. DATE</p> <p>DESIGNED BY RO DRAWN BY RO CHECKED BY RN</p>		<p>BENCH MARK: RIV. CO. BM 601-21-68, CALTRANS BRASS DISK SET IN CONC. WELL LOCATED IN CENTERLINE OF MONROE STREET 40' NW OF INDIANA AVENUE ELEVATION: 810.933</p>																					

INDEXED 12-26-01 left

MOUNTING CONCRETE PAD		PANEL M1		MAIN 100 A		
120/240 VOLTS 1 PHASE 3 WIRE		A.I.C. RATING 10000		BUS 100 A		
LOCATION	WATTAGE		CIRCUIT	CIRCUIT	WATTAGE	LOCATION
	ØA	ØB				
* SIGNS @ ACURA	876		20/1	1	2 20/1	1800 STREET LIGHTS
* SIGNS @ KARS YES	788		20/1	3	4 20/1	1800 STREET LIGHTS
* SIGNS @ VA	858		20/1	5	6 20/1	1800 STREET LIGHTS
* ENTRY LIGHTING	918		20/1	7	8 20/1	1800 STREET LIGHTS
* ENTRY LIGHTING	918		20/1	9	10 20/1	1800 STREET LIGHTS
			20/1	11	12 20/1	100 IRRIGATION CONTROL
			20/1	13	14 20/1	
			20/1	15	16 20/1	
			20/1	17	18 20/1	
			20/1	19	20 20/1	
			20/1	21	22 20/1	
			20/1	23	24 20/1	
			20/1	25	26 20/1	
			20/1	27	28 20/1	
			20/1	29	30 20/1	
			20/1	31	32 20/1	
			20/1	33	34 20/1	
			20/1	35	36 20/1	
			20/1	37	38 20/1	
			20/1	39	40 20/1	
			20/1	41	42 20/1	
WATTS ØA = 3452		ØB = 3056				
TOTAL WATTS = 7008		AMPS = 24.2 A		LCL = 36.5 A		
HIGH Ø WATTS = 3452		HIGH Ø AMPS = 32.1 A		HIGH Ø LCL = 41.2 A		

* CIRCUITS CONTROLLED BY LIGHTING CONTACTORS IN METER ENCLOSURE. KEEP STREET LIGHTS ON SEPERATE RELAYS FROM SIGNS AND OTHER LIGHTING. USE 2 POLE RELAYS ONLY.

MOUNTING CONCRETE PAD		PANEL M4		MAIN 100 A		
120/208 VOLTS 1 PHASE 3 WIRE		A.I.C. RATING 10000		BUS 100 A		
LOCATION	WATTAGE		CIRCUIT	CIRCUIT	WATTAGE	LOCATION
	ØA	ØB				
* SIGNS @ MITSUBISHI	858		20/1	1	2 20/1	1800 STREET LIGHTS
* SIGNS @ FRITTS	1038		20/1	3	4 20/1	1800 STREET LIGHTS
* SIGNS @ FRITTS	738		20/1	5	6 20/1	1800 STREET LIGHTS
* SIGNS @ LINCOLN	996		20/1	7	8 20/1	1170 STREET LIGHTS
* SIGNS @ LINCOLN	1134		20/1	9	10 20/1	1170 STREET LIGHTS
* SIGNS @ PONTIAC	996		20/1	11	12 20/1	1170 STREET LIGHTS
* SIGNS @ PONTIAC	1338		20/1	13	14 20/1	1170 STREET LIGHTS
* SIGNS @ MITSUBISHI	858		20/1	15	16 20/1	100 IRRIGATION CONTROL
* SIGNS @ JEEP	478		20/1	17	18 20/1	
* ROUNDABOUT	860		20/1	19	20 20/1	
			20/1	21	22 20/1	
			20/1	23	24 20/1	
			20/1	25	26 20/1	
			20/1	27	28 20/1	
			20/1	29	30 20/1	
			20/1	31	32 20/1	
			20/1	33	34 20/1	
			20/1	35	36 20/1	
			20/1	37	38 20/1	
			20/1	39	40 20/1	
			20/1	41	42 20/1	
WATTS ØA = 6604		ØB = 7356				
TOTAL WATTS = 13460		AMPS = 59.2 A		LCL = 72.1 A		
HIGH Ø WATTS = 7356		HIGH Ø AMPS = 61.3 A		HIGH Ø LCL = 76.6 A		

* CIRCUITS CONTROLLED BY LIGHTING CONTACTORS IN METER ENCLOSURE. KEEP STREET LIGHTS ON SEPERATE RELAYS FROM SIGNS AND OTHER LIGHTING. USE 2 POLE RELAYS ONLY.

MOUNTING CONCRETE PAD		PANEL M2		MAIN 100 A		
120/240 VOLTS 1 PHASE 3 WIRE		A.I.C. RATING 10000		BUS 100 A		
LOCATION	WATTAGE		CIRCUIT	CIRCUIT	WATTAGE	LOCATION
	ØA	ØB				
* SIGNS @ QUAD	720		20/1	1	2 20/1	1800 STREET LIGHTS
* SIGNS @ QUAD	876		20/1	3	4 20/1	1800 STREET LIGHTS
* SIGNS @ DUTTON	1014		20/1	5	6 20/1	1800 STREET LIGHTS
* SIGNS @ CHEVY	1258		20/1	7	8 20/1	1800 STREET LIGHTS
* SIGNS @ CHEVY	720		20/1	9	10 20/1	1800 STREET LIGHTS
* PEDESTAL @ WALTER'S	996		20/1	11	12 20/1	1800 STREET LIGHTS
			20/1	13	14 20/1	
			20/1	15	16 20/1	
			20/1	17	18 20/1	
			20/1	19	20 20/1	
			20/1	21	22 20/1	
			20/1	23	24 20/1	
			20/1	25	26 20/1	
			20/1	27	28 20/1	
			20/1	29	30 20/1	
			20/1	31	32 20/1	
			20/1	33	34 20/1	
			20/1	35	36 20/1	
			20/1	37	38 20/1	
			20/1	39	40 20/1	
			20/1	41	42 20/1	
WATTS ØA = 4684		ØB = 3910				
TOTAL WATTS = 8594		AMPS = 35.8 A		LCL = 44.8 A		
HIGH Ø WATTS = 4684		HIGH Ø AMPS = 39.1 A		HIGH Ø LCL = 48.8 A		

* CIRCUITS CONTROLLED BY LIGHTING CONTACTORS IN METER ENCLOSURE. KEEP STREET LIGHTS ON SEPERATE RELAYS FROM SIGNS AND OTHER LIGHTING. USE 2 POLE RELAYS ONLY.

MOUNTING CONCRETE PAD		PANEL M5		MAIN 100 A		
120/208 VOLTS 1 PHASE 3 WIRE		A.I.C. RATING 10000		BUS 100 A		
LOCATION	WATTAGE		CIRCUIT	CIRCUIT	WATTAGE	LOCATION
	ØA	ØB				
* SIGNS @ BUICK	858		20/1	1	2 20/1	1800 STREET LIGHTS
* SIGNS @ FRITTS	1338		20/1	3	4 20/1	650 STREET LIGHTS
* SIGNS @ CHRYSLER	858		20/1	5	6 20/1	1800 STREET LIGHTS
* SIGNS @ CHRYSLER	976		20/1	7	8 20/1	1800 STREET LIGHTS
* SIGNS @ BUICK	858		20/1	9	10 20/1	1800 STREET LIGHTS
* SIGNS @ CHRYSLER	956		20/1	11	12 20/1	1800 STREET LIGHTS
* ROUNDABOUT	860		20/1	13	14 20/1	
			20/1	15	16 20/1	
			20/1	17	18 20/1	
			20/1	19	20 20/1	
			20/1	21	22 20/1	
			20/1	23	24 20/1	
			20/1	25	26 20/1	
			20/1	27	28 20/1	
			20/1	29	30 20/1	
			20/1	31	32 20/1	
			20/1	33	34 20/1	
			20/1	35	36 20/1	
			20/1	37	38 20/1	
			20/1	39	40 20/1	
			20/1	41	42 20/1	
WATTS ØA = 5254		ØB = 4600				
TOTAL WATTS = 9854		AMPS = 41 A		LCL = 51.25 A		
HIGH Ø WATTS = 5254		HIGH Ø AMPS = 43.8 A		HIGH Ø LCL = 54.7 A		


* CIRCUITS CONTROLLED BY LIGHTING CONTACTORS IN METER ENCLOSURE. KEEP STREET LIGHTS ON SEPERATE RELAYS FROM SIGNS AND OTHER LIGHTING. USE 2 POLE RELAYS ONLY.

MOUNTING CONCRETE PAD		PANEL M3		MAIN 100 A		
120/208 VOLTS 1 PHASE 3 WIRE		A.I.C. RATING 10000		BUS 100 A		
LOCATION	WATTAGE		CIRCUIT	CIRCUIT	WATTAGE	LOCATION
	ØA	ØB				
* SIGNS @ DUTTON	958		20/1	1	2 20/1	1800 STREET LIGHTS
* SIGNS @ DUTTON	996		20/1	3	4 20/1	1800 STREET LIGHTS
* SIGNS @ CHEVY	1014		20/1	5	6 20/1	1800 STREET LIGHTS
* SIGNS @ CHEVY	1160		20/1	7	8 20/1	1800 STREET LIGHTS
* SIGNS @ MOSS	720		20/1	9	10 20/1	1800 STREET LIGHTS
* SIGNS @ MOSS	996		20/1	11	12 20/1	1800 STREET LIGHTS
* ROUNDABOUT	1100		20/1	13	14 20/1	1800 STREET LIGHTS
* SIGN @ CARWASH	600		20/1	15	16 20/1	1800 STREET LIGHTS
			20/1	17	18 20/1	100 IRRIGATION CONTROL
			20/1	19	20 20/1	
			20/1	21	22 20/1	
			20/1	23	24 20/1	
			20/1	25	26 20/1	
			20/1	27	28 20/1	
			20/1	29	30 20/1	
			20/1	31	32 20/1	
			20/1	33	34 20/1	
			20/1	35	36 20/1	
			20/1	37	38 20/1	
			20/1	39	40 20/1	
			20/1	41	42 20/1	
WATTS ØA = 5780		ØB = 5132				
TOTAL WATTS = 10912		AMPS = 45.3 A		LCL = 56.6 A		
HIGH Ø WATTS = 5780		HIGH Ø AMPS = 47.8 A		HIGH Ø LCL = 59.7 A		

* CIRCUITS CONTROLLED BY LIGHTING CONTACTORS IN METER ENCLOSURE. KEEP STREET LIGHTS ON SEPERATE RELAYS FROM SIGNS AND OTHER LIGHTING. USE 2 POLE RELAYS ONLY.

MOUNTING CONCRETE PAD		PANEL M6		MAIN 100 A		
120/240 VOLTS 1 PHASE 3 WIRE		A.I.C. RATING 10000		BUS 100 A		
LOCATION	WATTAGE		CIRCUIT	CIRCUIT	WATTAGE	LOCATION
	ØA	ØB				
* SIGNS @ TOYOTA TK	734		20/1	1	2 20/1	1800 STREET LIGHTS
* SIGNS @ CAR STORE	440		20/1	3	4 20/1	1800 STREET LIGHTS
* SIGNS @ TOYOTA	960		20/1	5	6 20/1	1040 STREET LIGHTS
* ENTRY LIGHTING	996		20/1	7	8 20/1	520 STREET LIGHTS
* ENTRY LIGHTING	996		20/1	9	10 20/1	520 STREET LIGHTS
* SIGNS @ VOLVO	996		20/1	11	12 20/1	1800 STREET LIGHTS
* SIGNS @ BMW	996		20/1	13	14 20/1	1800 STREET LIGHTS
			20/1	15	16 20/1	
			20/1	17	18 20/1	100 IRRIGATION CONTROL
			20/1	19	20 20/1	
			20/1	21	22 20/1	
			20/1	23	24 20/1	
			20/1	25	26 20/1	
			20/1	27	28 20/1	
			20/1	29	30 20/1	
			20/1	31	32 20/1	
			20/1	33	34 20/1	
			20/1	35	36 20/1	
			20/1	37	38 20/1	
			20/1	39	40 20/1	
			20/1	41	42 20/1	
WATTS ØA = 5608		ØB = 3994				
TOTAL WATTS = 9602		AMPS = 40 A		LCL = 50 A		
HIGH Ø WATTS = 5608		HIGH Ø AMPS = 46.7 A		HIGH Ø LCL = 58.4 A		

* CIRCUITS CONTROLLED BY LIGHTING CONTACTORS IN METER ENCLOSURE. KEEP STREET LIGHTS ON SEPERATE RELAYS FROM SIGNS AND OTHER LIGHTING. USE 2 POLE RELAYS ONLY.

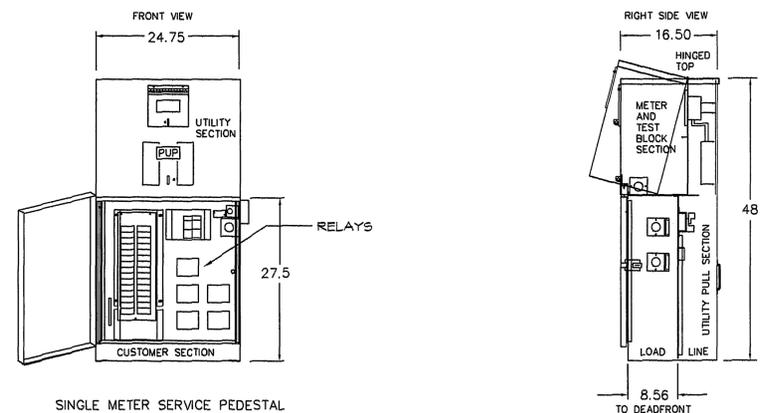

SINGLE METER SERVICE PEDESTAL




USP-24 MODEL SERIES

- STANDARD FEATURES**
- TEST BLOCKS TO MEET CITY OF RIVERSIDE SPECIFICATIONS (MUST HAVE NEUTRAL IN TEST BLOCK AREA)
 - UTILITY LANDING LUGS - INCLUDING NEUTRAL 250 KCMIL
 - METER SOCKET WITH TEST BLOCKS (120/240) 4 JAW
 - METER SOCKET WITH TEST BLOCKS (120/208) 5 JAW
 - STANDARD VOLTAGE 120/240 VAC OR 120/208 VAC 1 PHASE 3 WIRE
 - ACCOMMODATES 30 CIRCUIT INTERIOR MAXIMUM

- SPECIFICATIONS**
- COMPLIES WITH EUSERC STANDARDS & DWG. 308
 - 14 GA. NEMA 3R CONSTRUCTION
 - PHOTOCELL SOCKET W/ SHIELD
 - FABRICATED FROM STAINLESS STEEL
 - ALL FACTORY WIRING 600 VOLT RATED COPPER
 - ALL COMPONENTS UL LISTED
 - ALL EXTERIOR DOORS AND COVERS PADLOCKABLE
 - UTILITY COVERS SEALABLE

MI METER PEDESTAL DETAILS

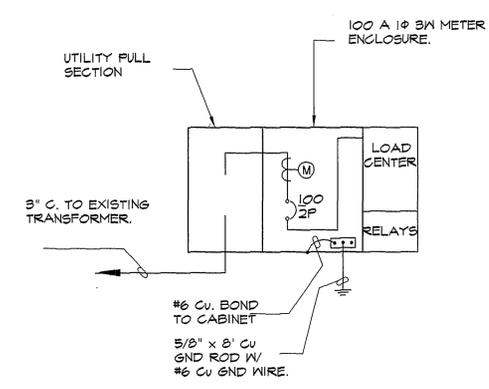

SINGLE LINE DRAWING

C:\AUTOMALL\SHEET10 Mon Dec 1 12:26:42 1997

Underground Service Alert Call: TOLL FREE 1 - 800 422 - 4133 TWO WORKING DAYS BEFORE YOU DIG	PRIVATE ENGINEERING NOTE CONSTRUCTION CONTRACTOR AGREES THAT IN ACCORDANCE WITH GENERALLY ACCEPTED CONSTRUCTION PRACTICES, CONSTRUCTION CONTRACTOR WILL BE REQUIRED TO ASSUME SOLE AND COMPLETE RESPONSIBILITY FOR USE SITE CONDITIONS DURING THE COURSE OF CONSTRUCTION OF THE PROJECT, INCLUDING SAFETY OF ALL PERSONS AND PROPERTY, THAT THIS REQUIREMENT SHALL BE MADE TO APPLY CONTINUOUSLY AND NOT BE LIMITED TO NORMAL WORKING HOURS, AND CONTRACTOR SHALL BE RESPONSIBLE FOR OBTAINING NECESSARY PERMITS AND HOLDING PERMITS PROFESSIONAL HARMLESS FROM ANY AND ALL LIABILITY, LOSS OR ALLEGED LOSS IN CONNECTION WITH THE PERFORMANCE OF WORK ON THIS PROJECT, INCLUDING LIABILITY ARISING FROM THE SOLE NEGLIGENCE OF DESIGN PROFESSIONAL.	WEST COAST DESIGN ELECTRICAL AND LIGHTING ENGINEERS 26692 PASEO PRILLO, SUITE 200 SAN JUAN CAPISTRANO, CA 92675 (714) 240-1918 FAX 240-1782	SCALE: NONE BENCH MARK: CIV. CO. BM 601-21-68, CALTRANS BRASS DISK SET IN CONC. WELL LOCATED IN CENTERLINE OF MONROE STREET 40' NW OF INDIANA AVENUE DATE: OCTOBER 1997	MARK: REVISIONS APPR. DATE DESIGNED BY: RO DRAWN BY: RO CHECKED BY: RN	CITY OF RIVERSIDE, DEPARTMENT OF PUBLIC WORKS	IN THE CITY OF RIVERSIDE, COUNTY OF RIVERSIDE STATE OF CALIFORNIA AUTO CENTER RENOVATION PLAN PANEL SCHEDULES AUTO DRIVE	STREET LIGHTING R-3471 SHEET E10 OF 10
					APPROVED BY: _____ BY: _____ DATE: _____ PRINCIPAL ENGR. PARK DEPARTMENT TRAFFIC DIVISION CHIEF P. WENGER	APPROVED BY: _____ DIRECTOR OF PUBLIC WORKS	FOR: RIVERSIDE AUTO CENTER ASSESSMENT DISTRICT FILE NO.: 9613380

INDEXED 12-26-01 L4